


비전대 스튜디오 조성공사

2021.02

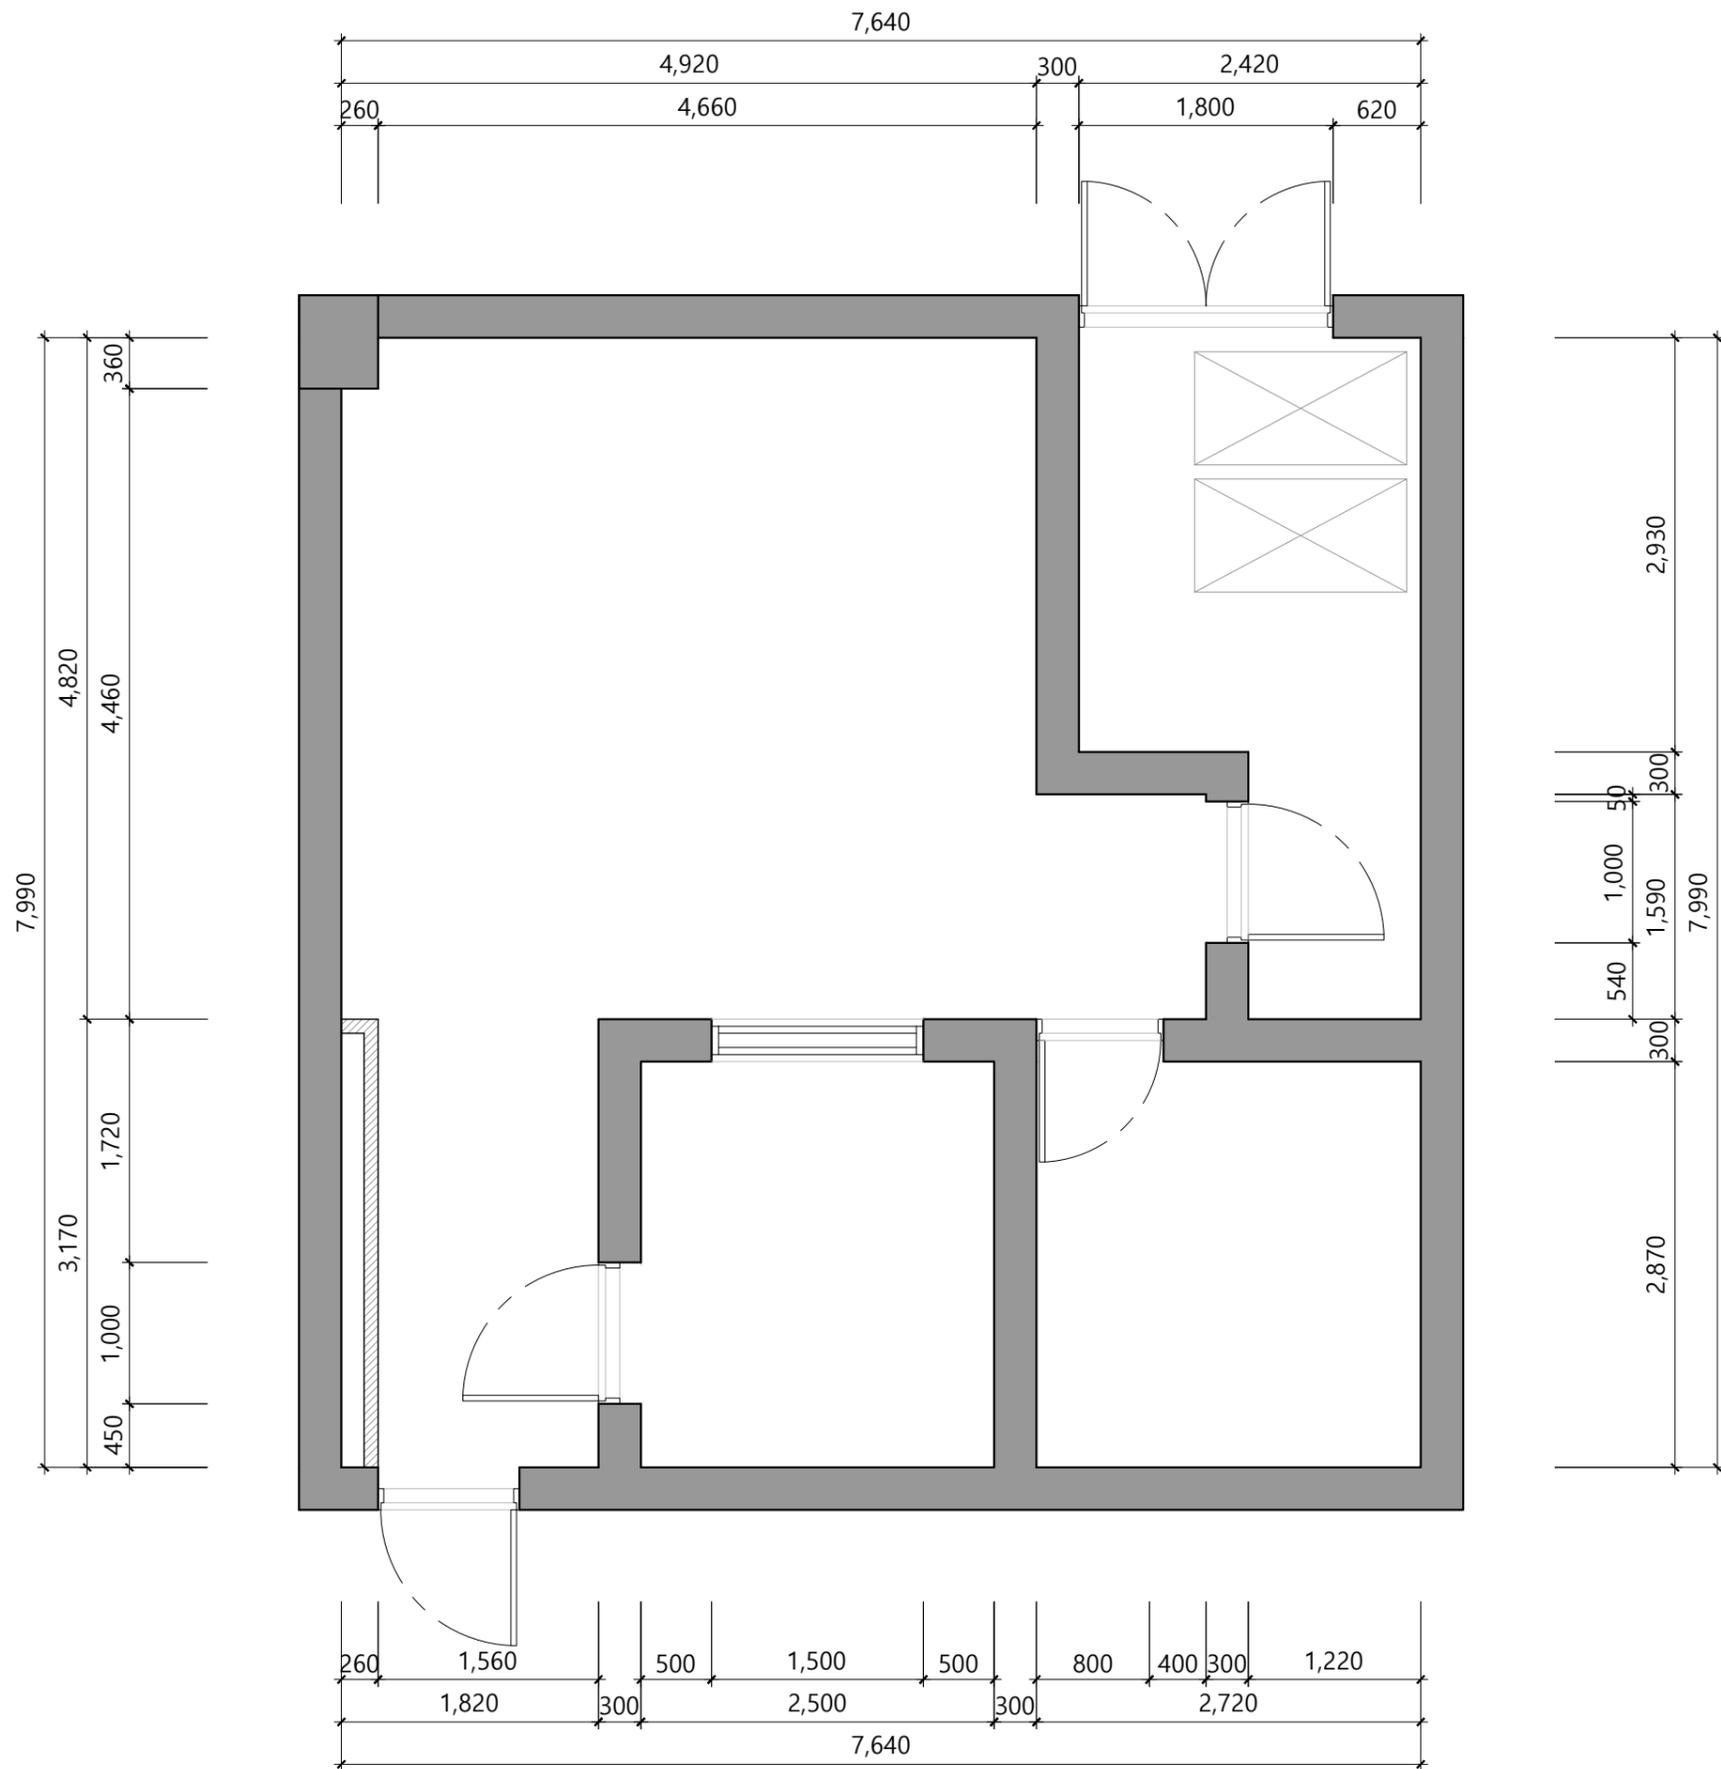

Project Title

비전관 스튜디오
조성공사

Approved By

Note

- * 면적 : 61.1m²(18.5py)
- * 천정고 : 2,360+200
- * SLAB : 3,500+200

Drawing Title

FLOOR PLAN
(변경전)

Designed By

Drawn By

Checked By

Date 2021. 02.

Scale 1 / 50


Drawing No. I-02

Sheet No.

FLOOR PLAN(변경전)

SCALE
1/50

1

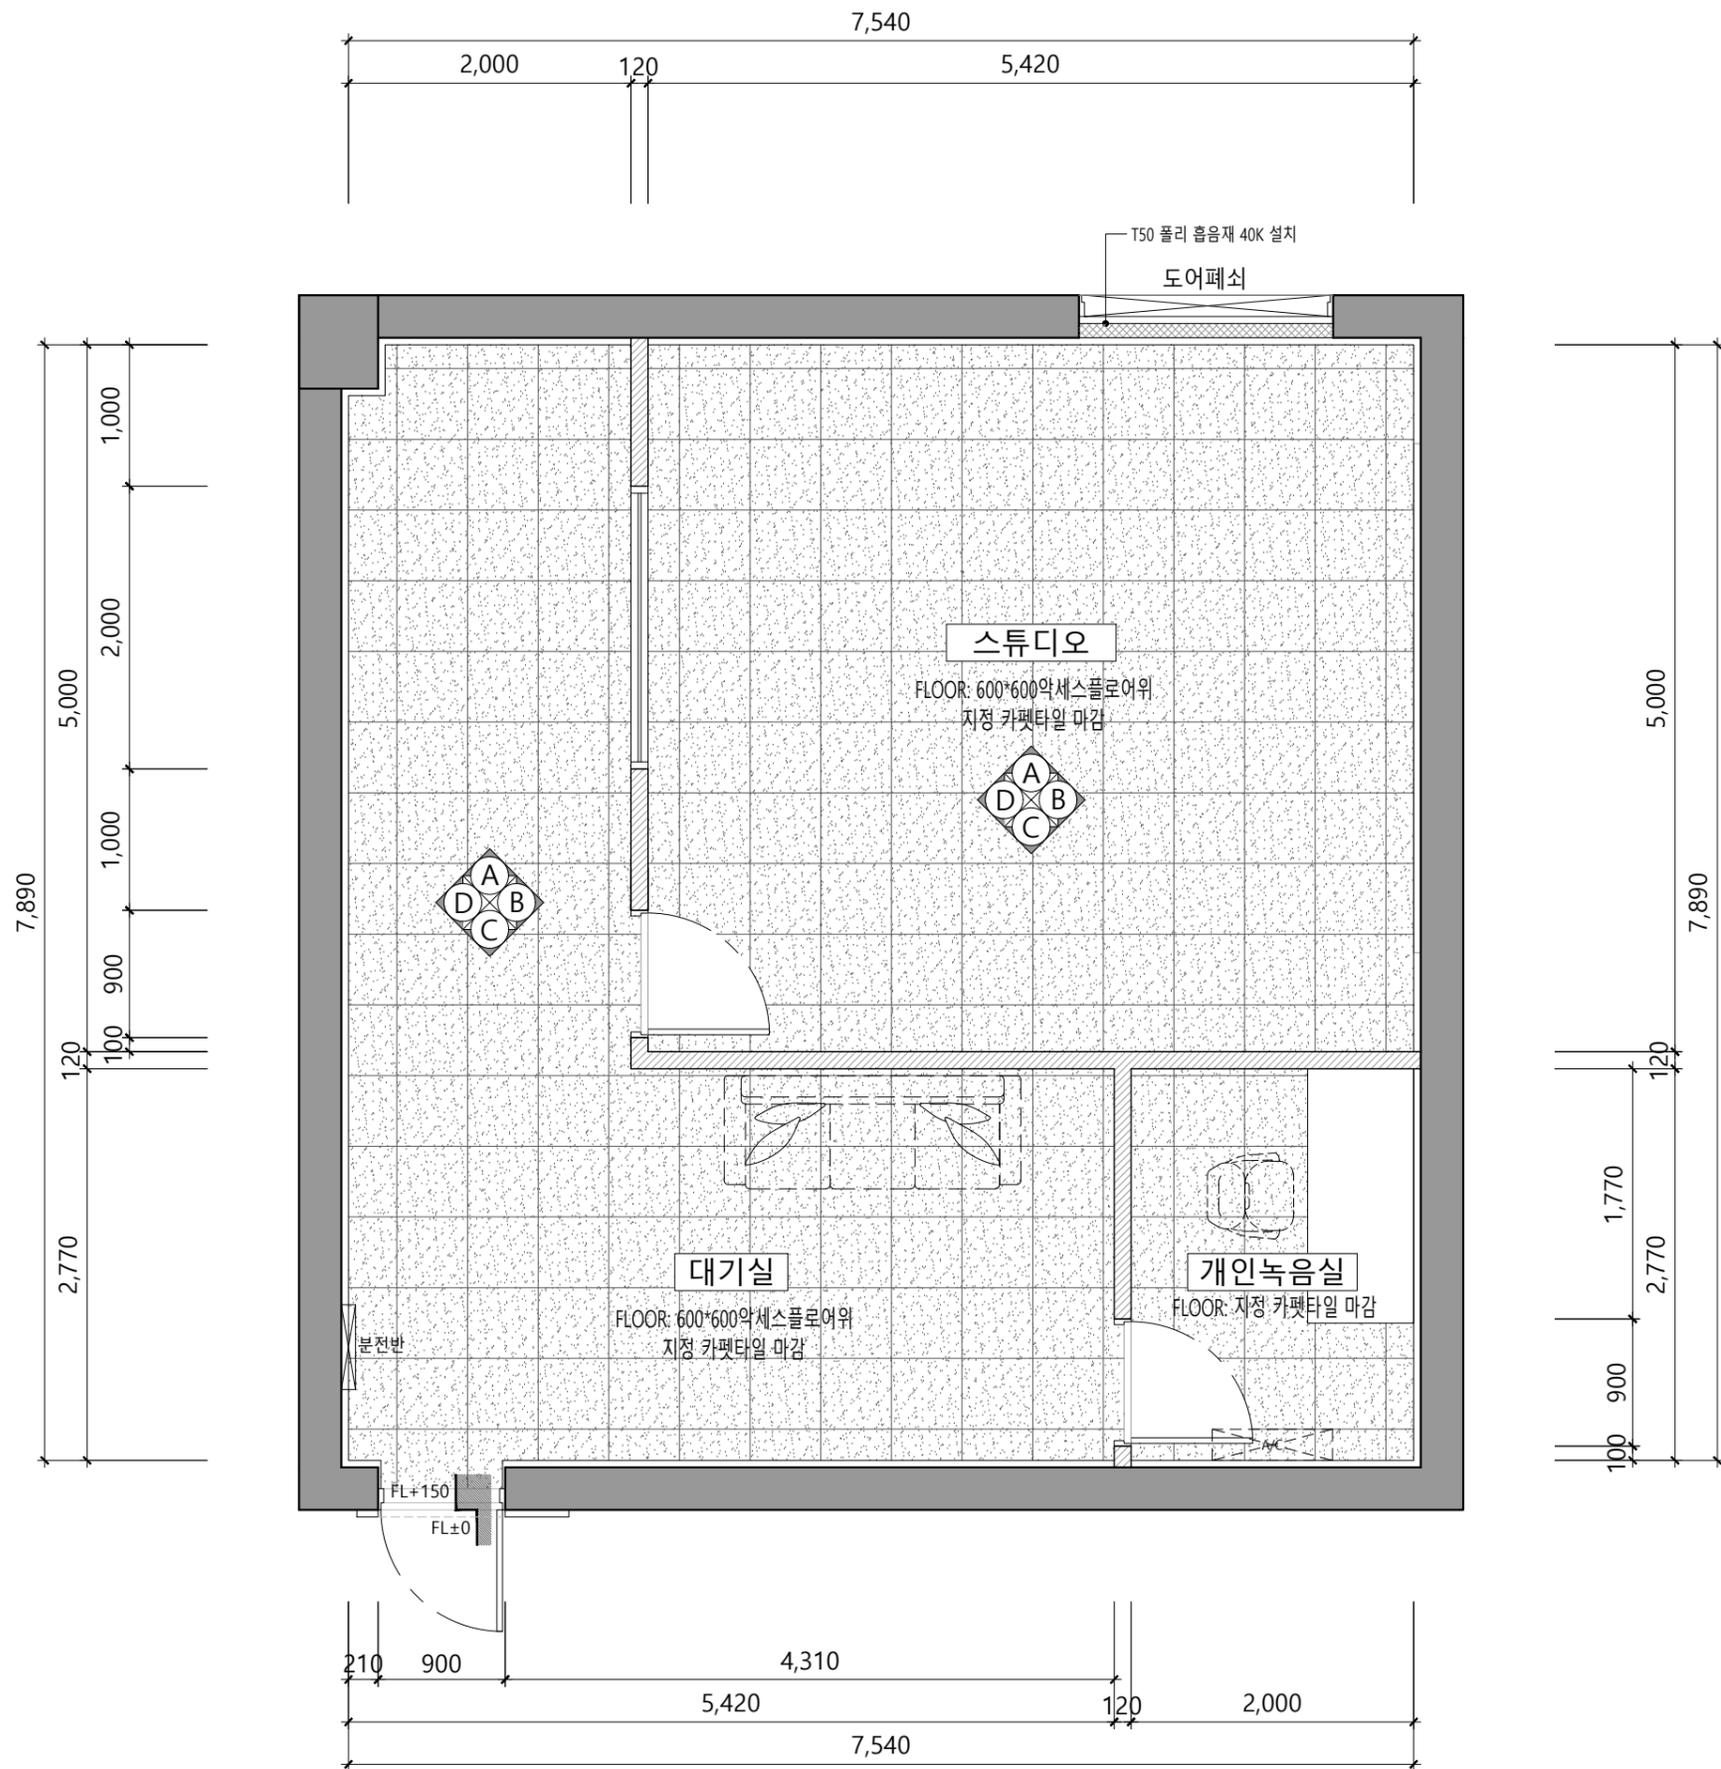

Project Title

비전관 스튜디오
조성공사

Approved By

Note

- * 면적 : 61.1m2(18.5py)
- * 천정고 : 2,360
- * SLAB : 3,500

Drawing Title

FLOOR PLAN

Designed By

Drawn By

Checked By

Date 2021. 02.

Scale 1 / 50


Drawing No. I-03

Sheet No.

FLOOR PLAN

SCALE
1/50

1

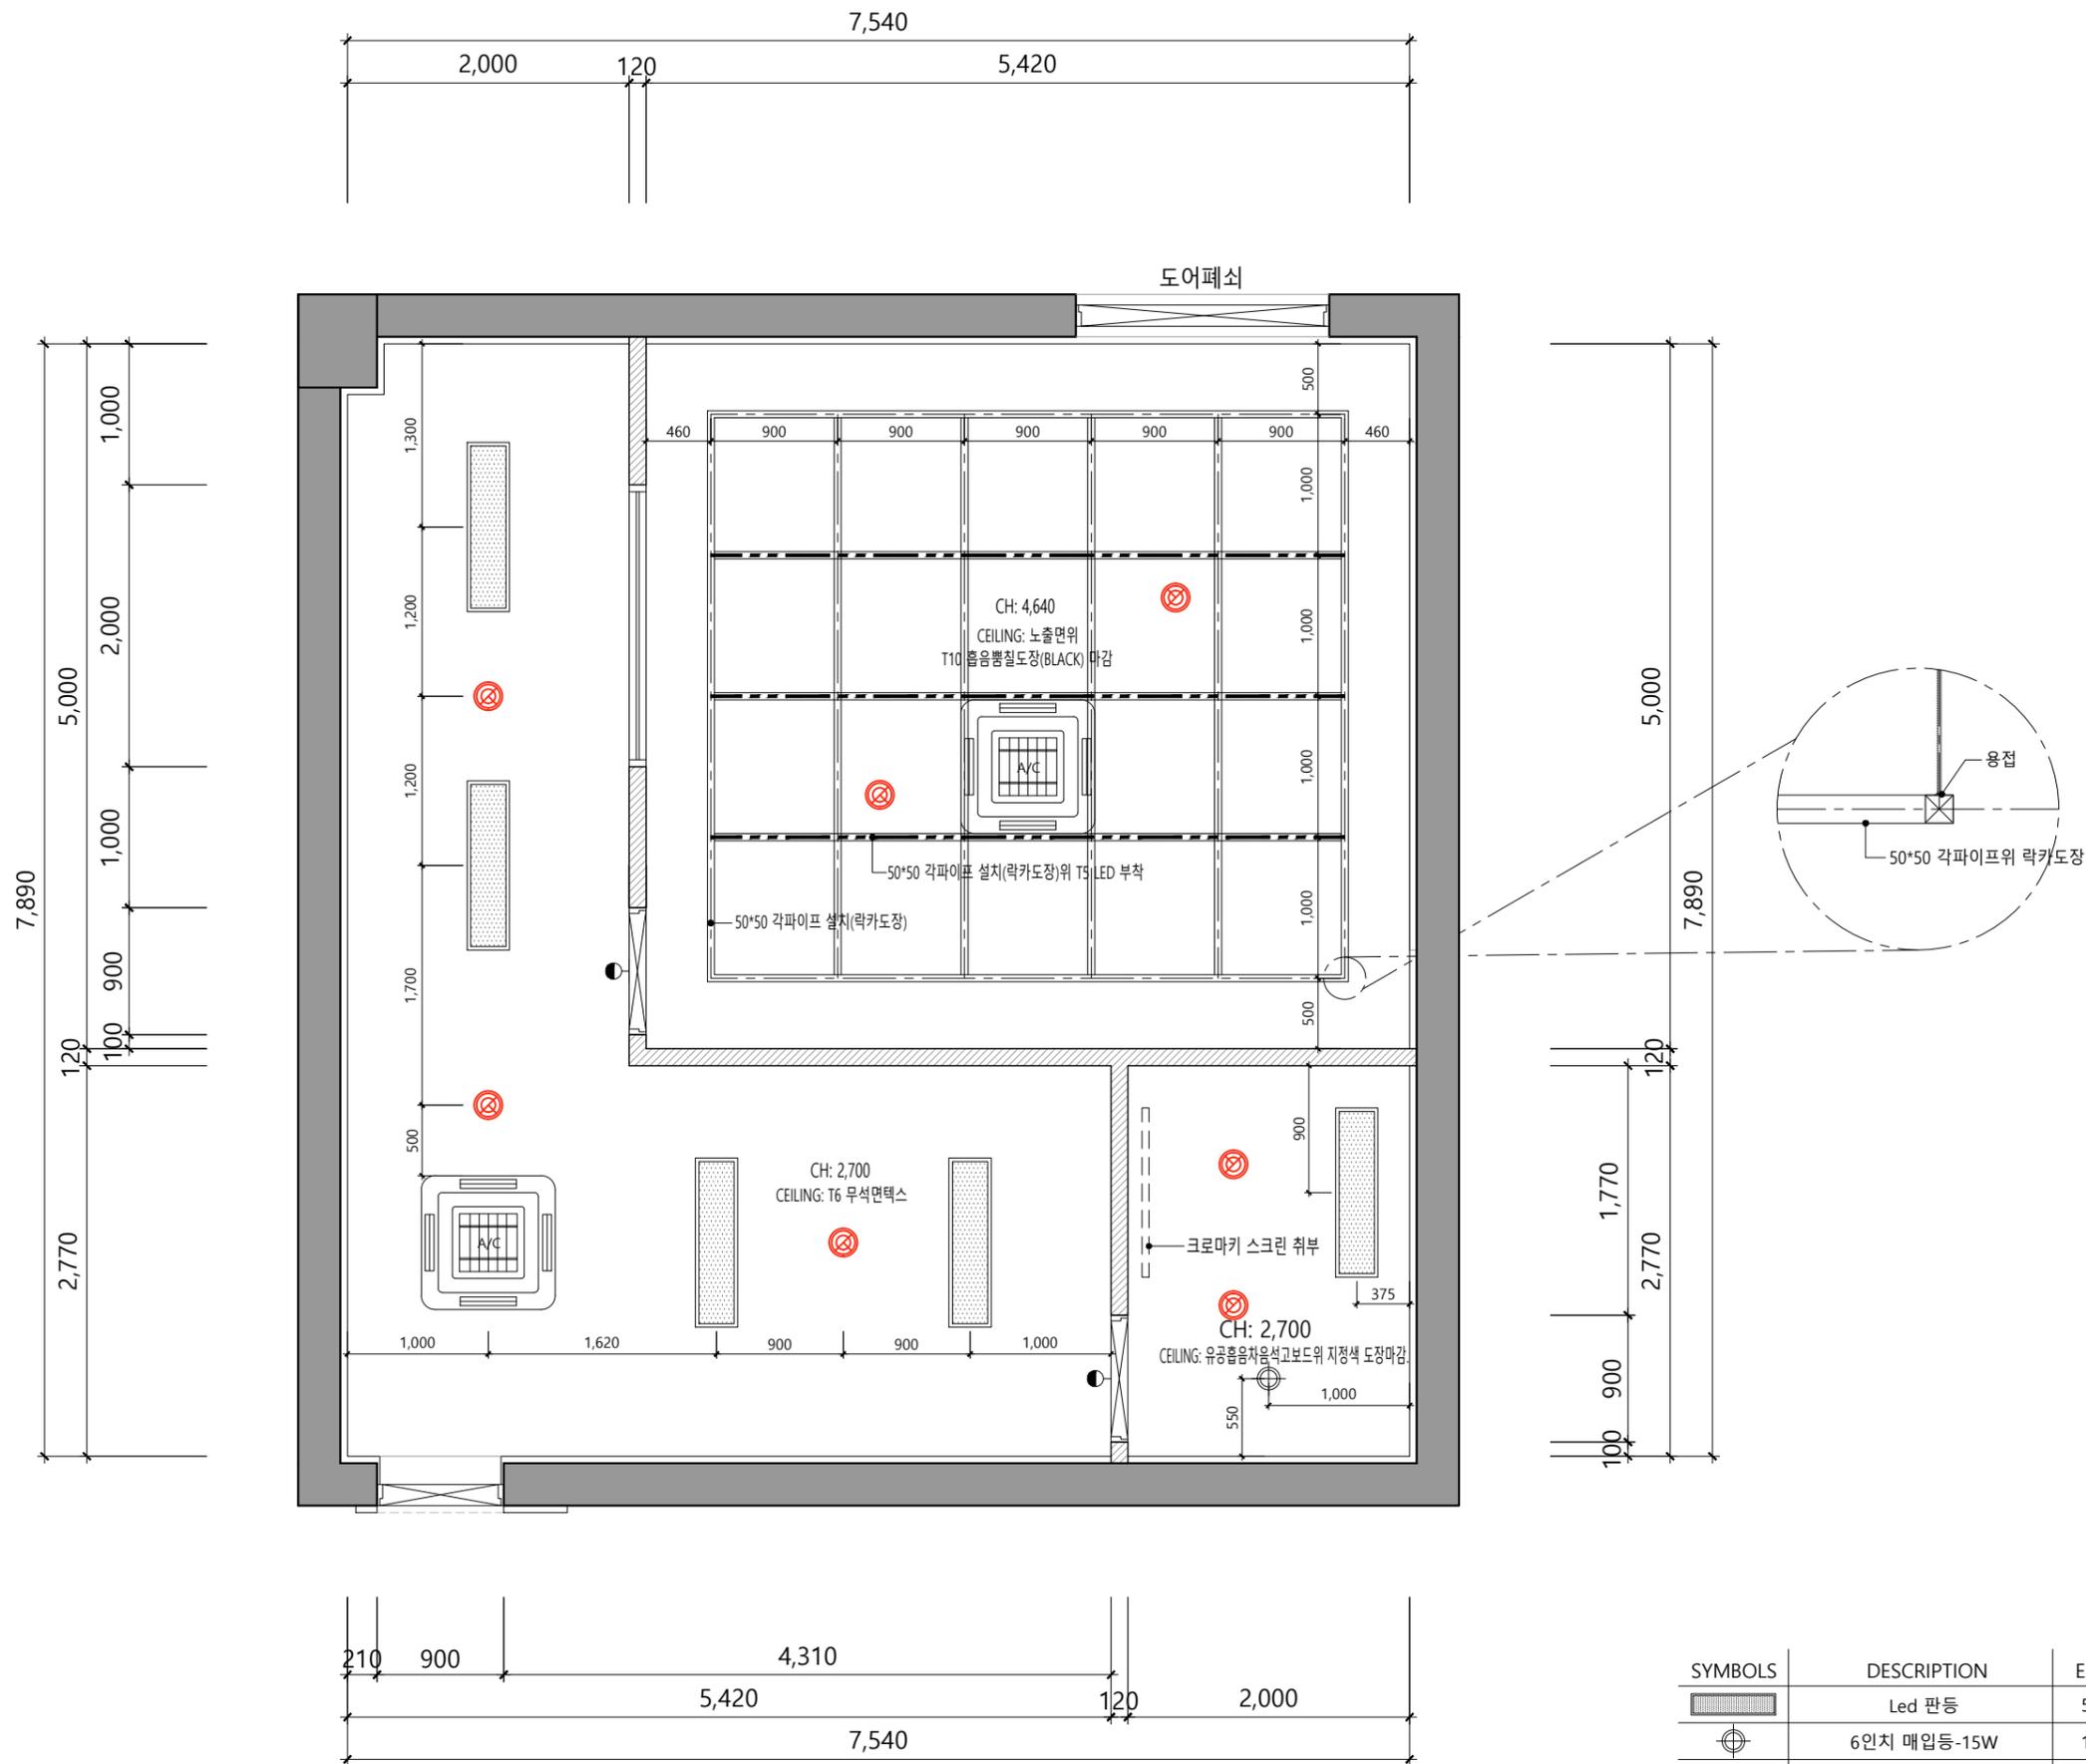

Project Title
**비전관 스튜디오
 조성공사**

Approved By _____

Note
 * 면적 : 61.1m²(18.5py)
 * 천정고 : 2,360
 * SLAB : 3,500

Drawing Title
CEILING PLAN

Designed By _____
 Drawn By _____
 Checked By _____

Date 2021. 02.
 Scale 1 / 50
 Drawing No. I-04
 Sheet No. _____

| SYMBOLS | DESCRIPTION | EA |
|---------|----------------|----|
| | Led 판등 | 5 |
| | 6인치 매입등-15W | 1 |
| | T5 LED (W=900) | 15 |





CEILING PLAN SCALE 1/50 **1**

Project Title

비전관 스튜디오
조성공사

Approved By

Note

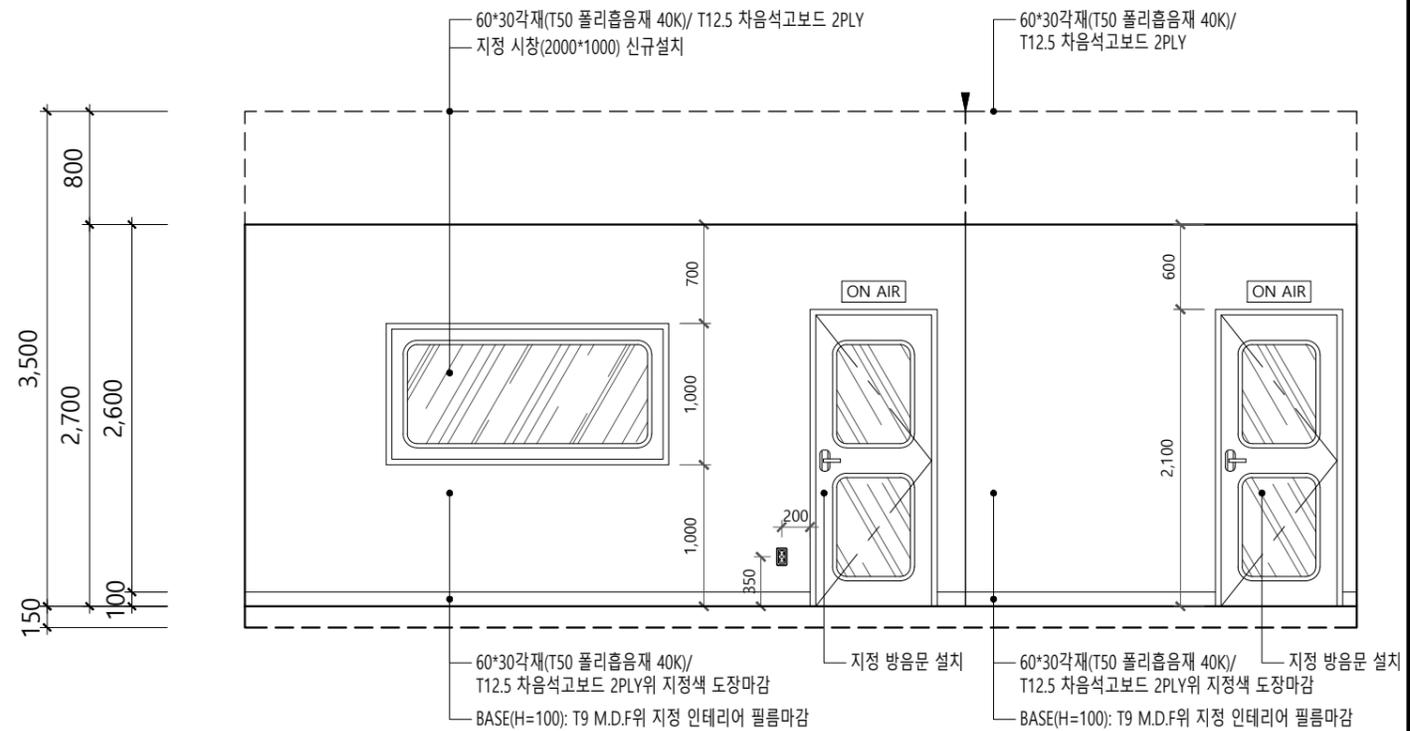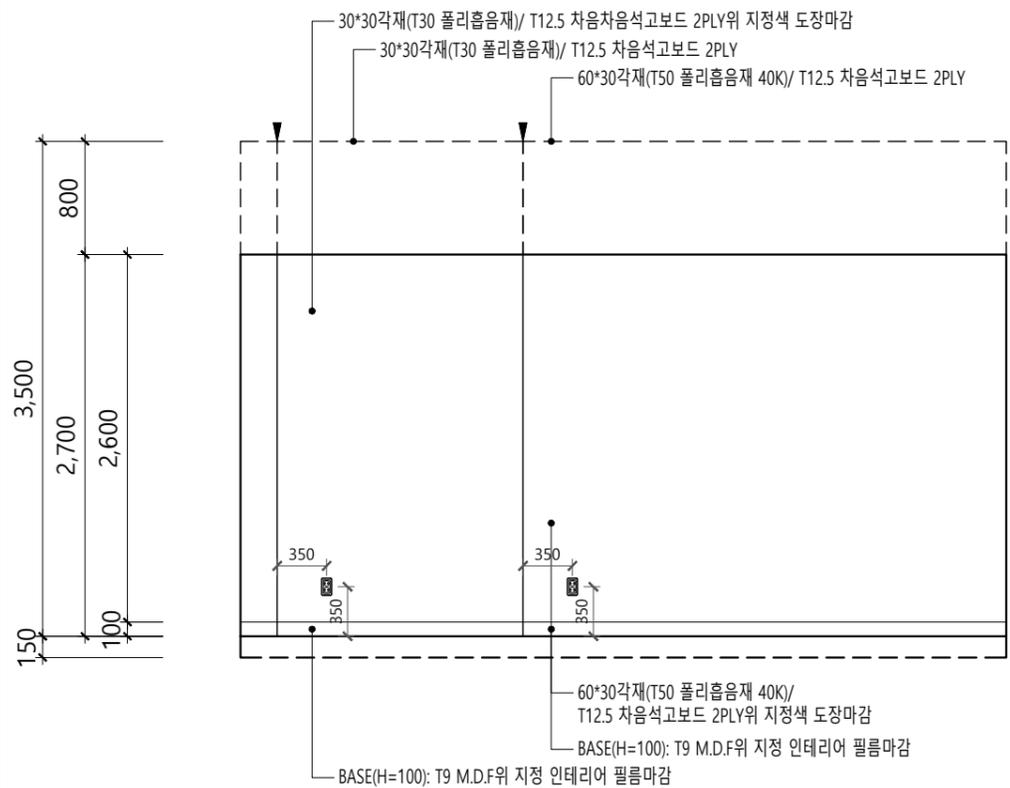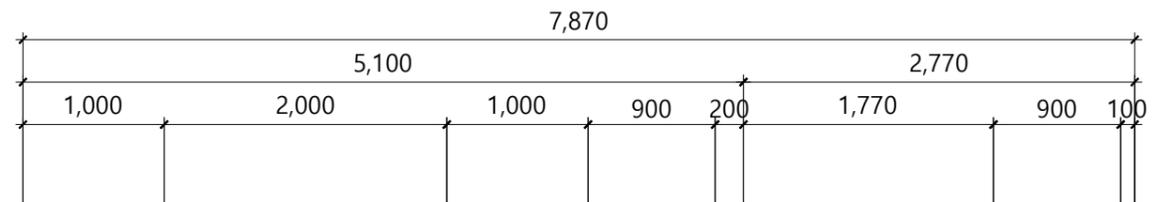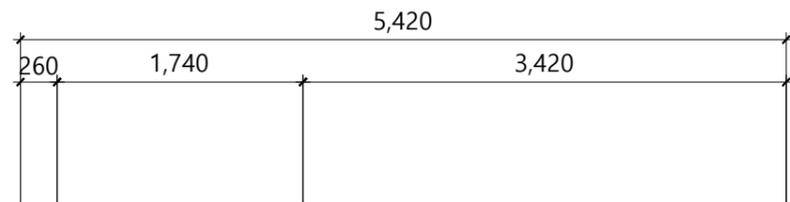

ELEVATION-A (대기실 입면도)

SCALE
1/50

1

ELEVATION-B (대기실 입면도)

SCALE
1/50

2

Drawing Title

ELEVATION-A,B
(대기실)

Designed By

Drawn By





Checked By

Date 2020. 12.

Scale 1 / 50

Drawing No. I-05

Sheet No.

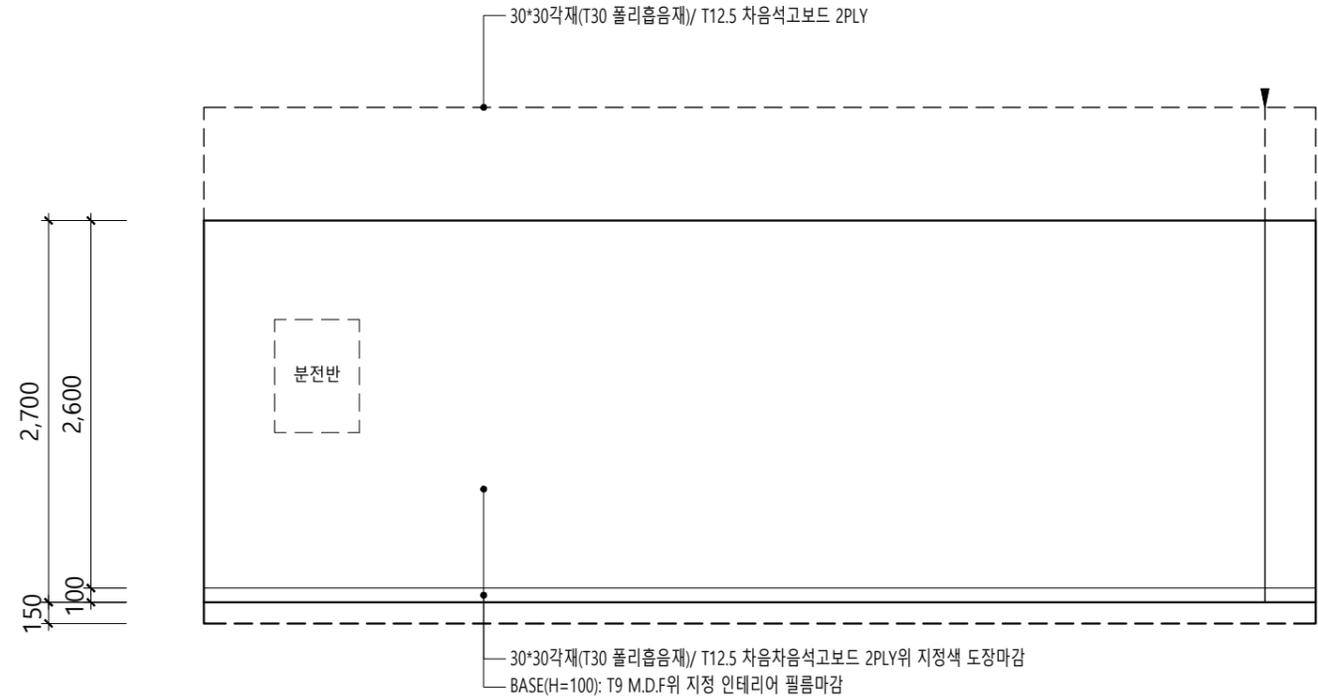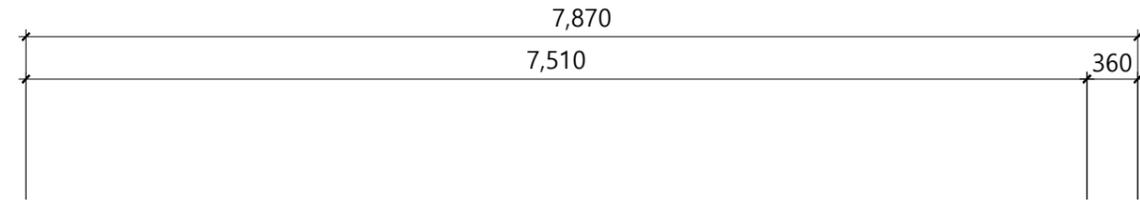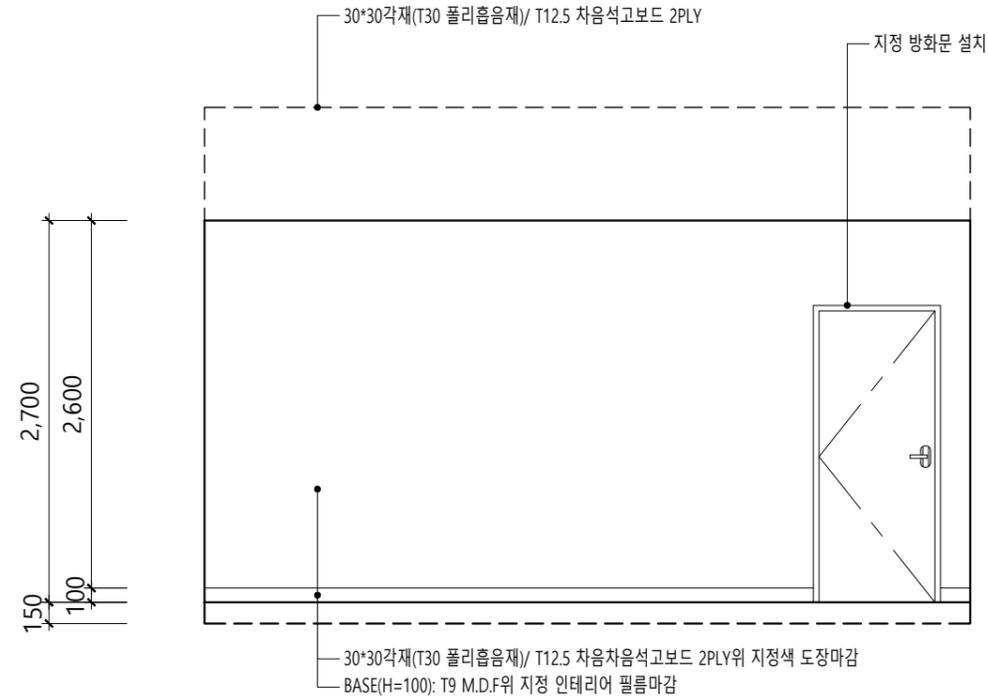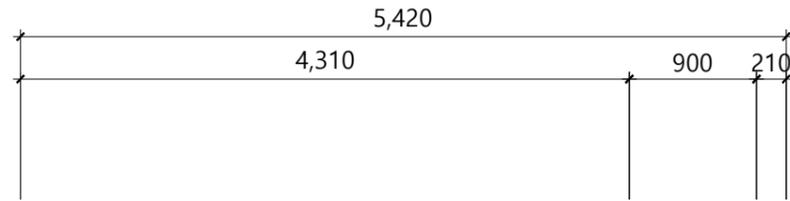

Project Title

비전관 스튜디오
조성공사

Approved By

Note

Drawing Title

ELEVATION-C,D
(대기실)

Designed By

Drawn By

Checked By

Date 2020. 12.

Scale 1 / 50

Drawing No. I-06

Sheet No.

ELEVATION-C (대기실 입면도)

SCALE
1/50

1

ELEVATION-D (대기실 입면도)

SCALE
1/50





2

Project Title

비전관 스튜디오
조성공사

Approved By

Note

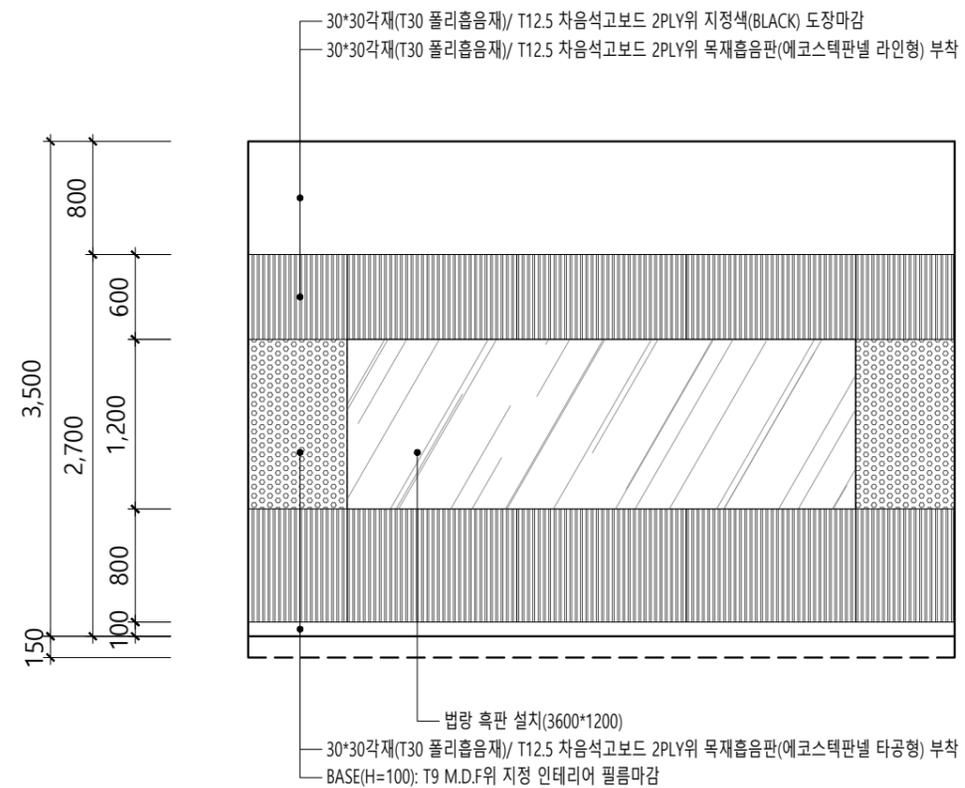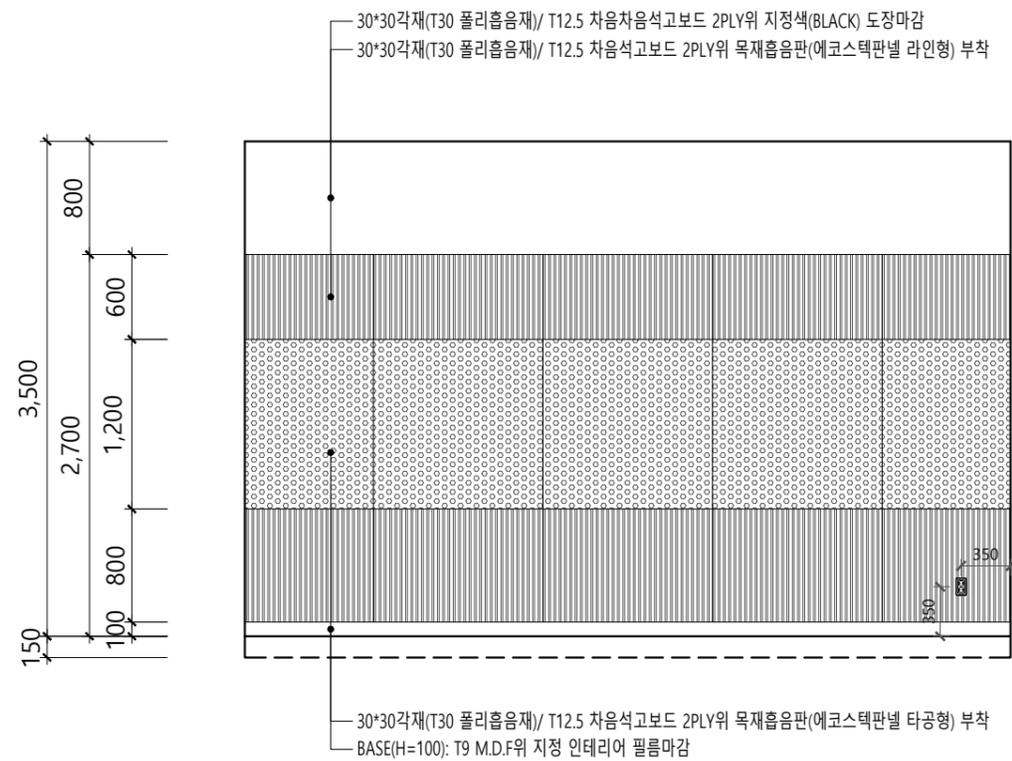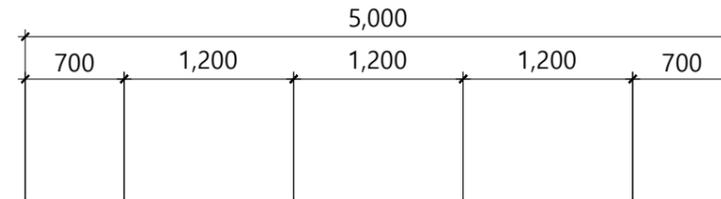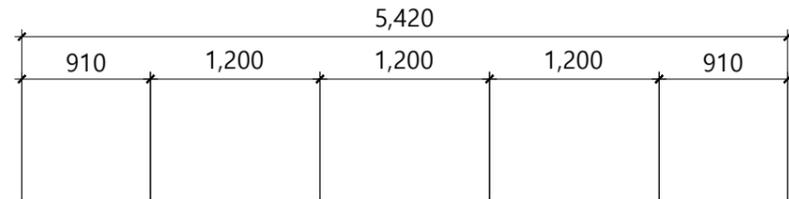

ELEVATION-A (스튜디오 입면도)

SCALE
1/50

1

ELEVATION-B (스튜디오 입면도)

SCALE
1/50

2

Drawing Title

ELEVATION-A,B
(스튜디오)

Designed By

Drawn By

Checked By

Date 2020. 12.

Scale 1 / 50

Drawing No. I-07





Sheet No.

Project Title

비전관 스튜디오
조성공사

Approved By

Note

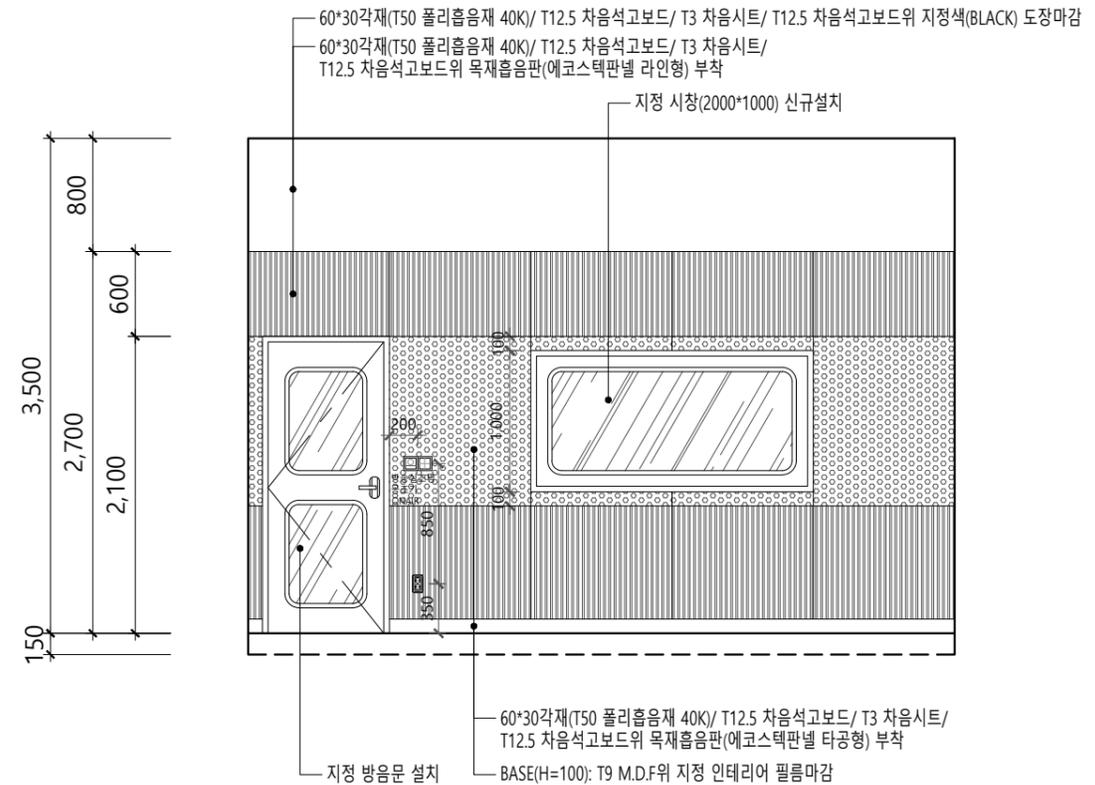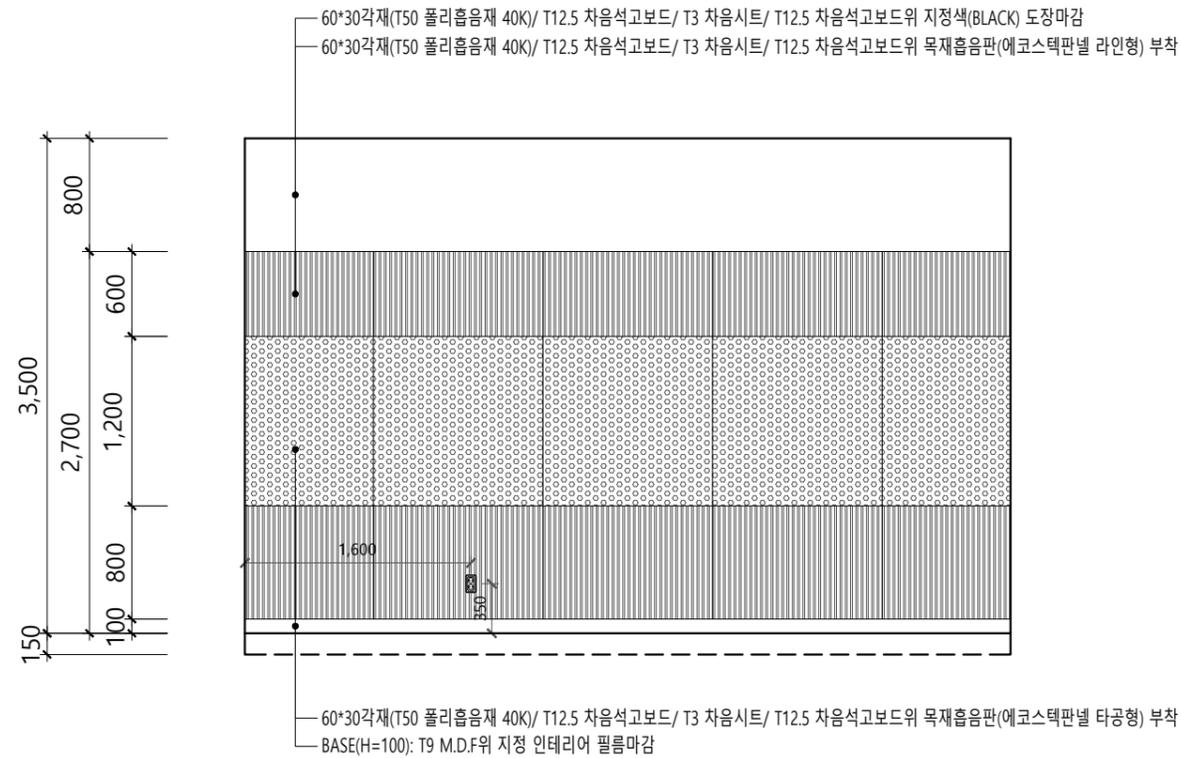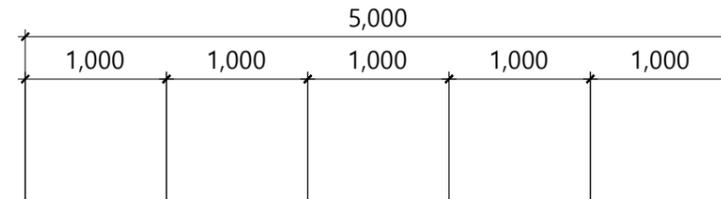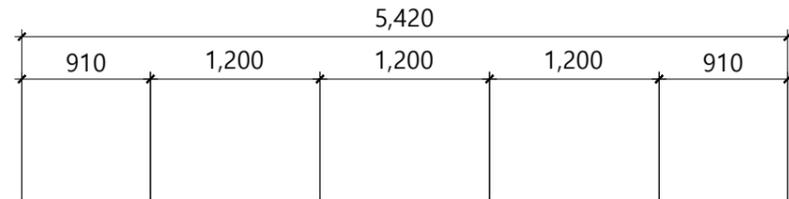

ELEVATION-C (스튜디오 입면도)

SCALE
1/50

1

ELEVATION-D (스튜디오 입면도)

SCALE
1/50

2

Drawing Title

ELEVATION-C,D
(스튜디오)

Designed By

Drawn By


Checked By

Date 2020. 12.

Scale 1 / 50

Drawing No. I-08


Sheet No.

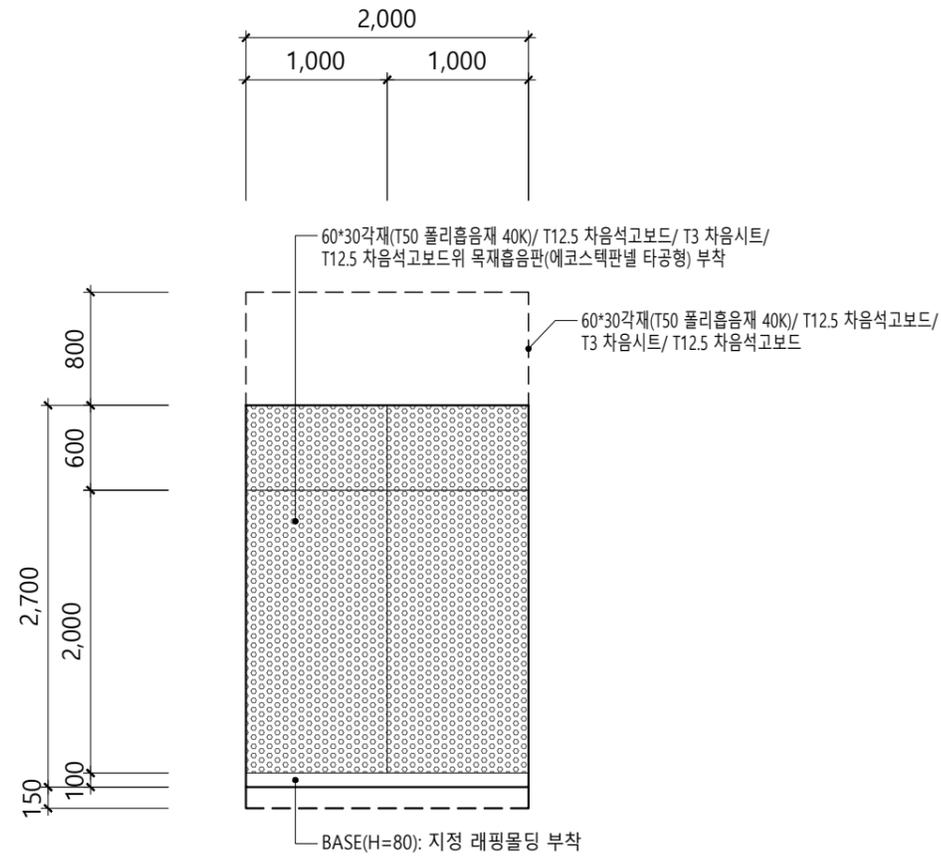

ELEVATION-A (개인녹음실 입면도)

SCALE
1/50


1

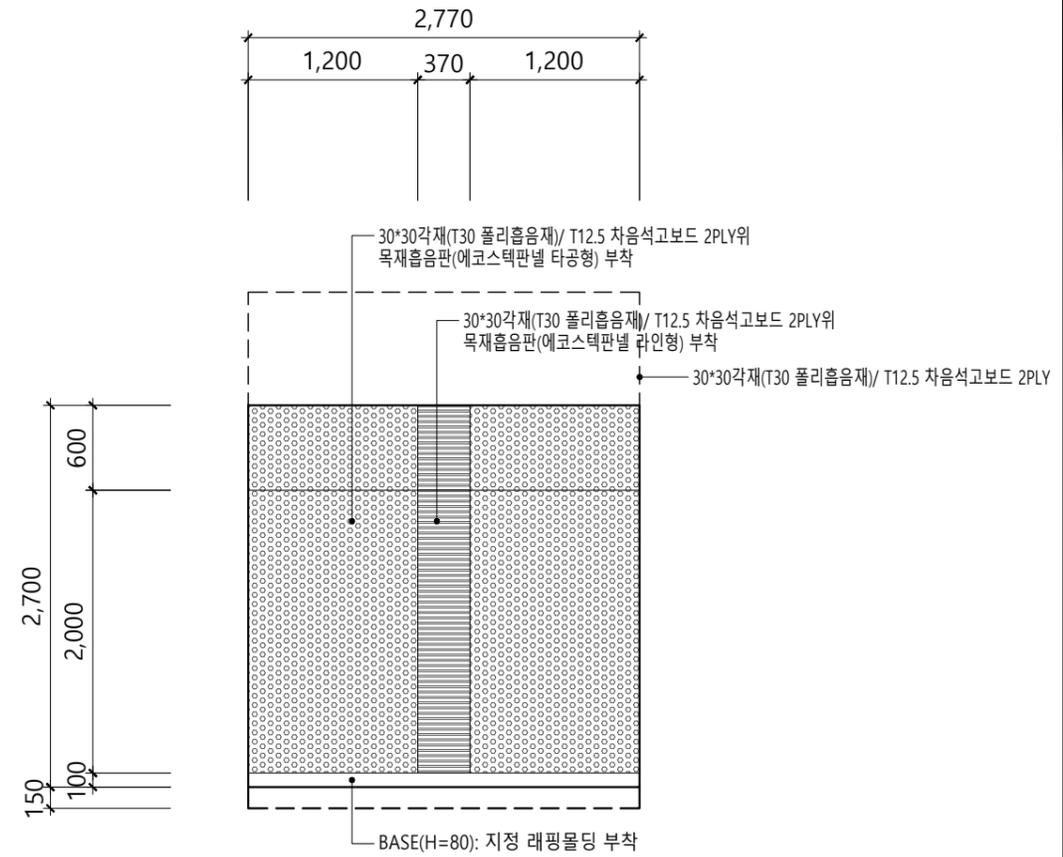

ELEVATION-B (개인녹음실 입면도)

SCALE
1/50


2

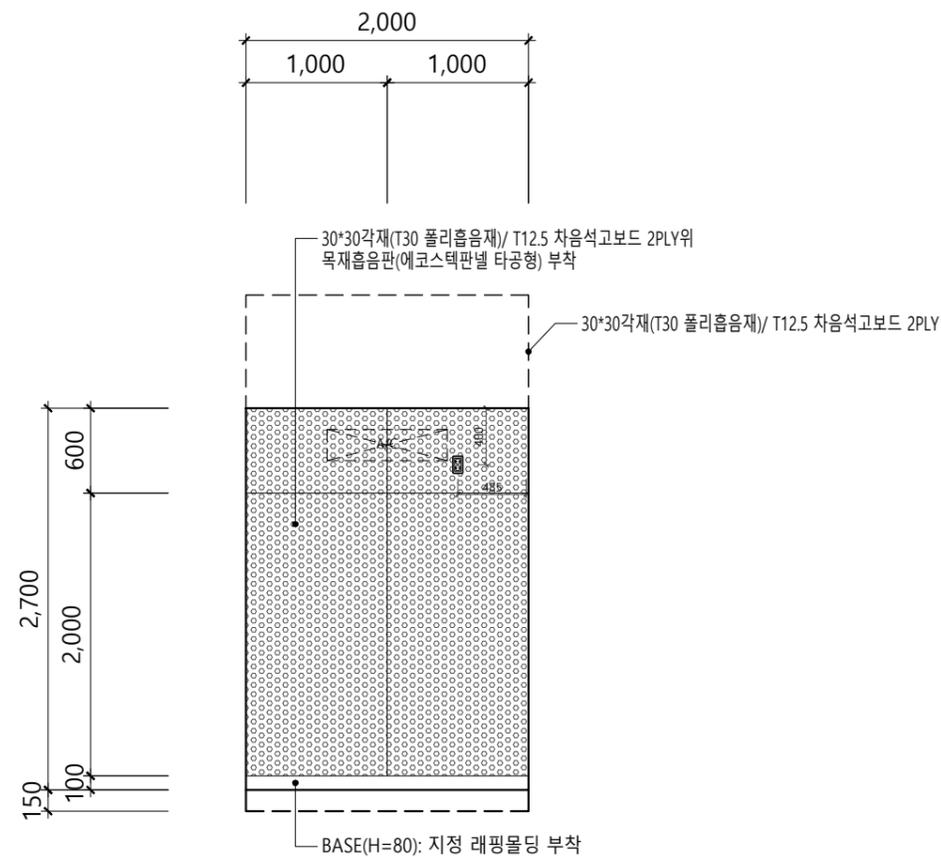

ELEVATION-C (개인녹음실 입면도)

SCALE
1/50

3

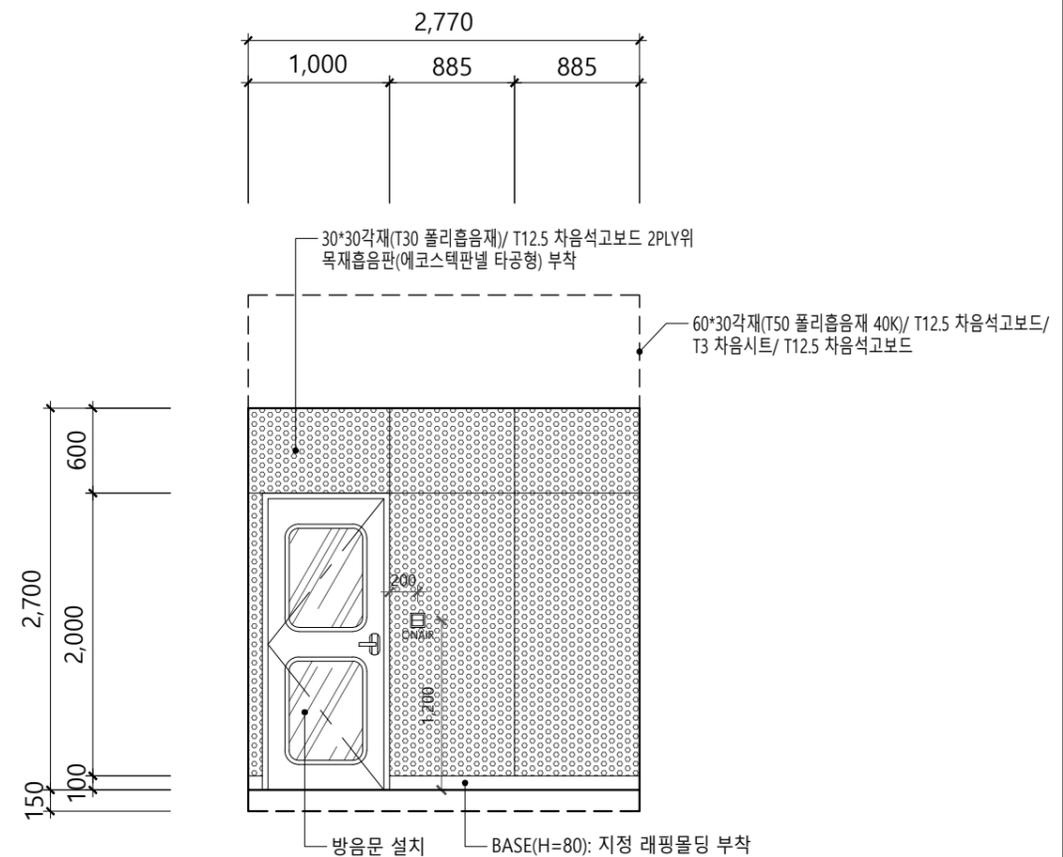

ELEVATION-D (개인녹음실 입면도)

SCALE
1/50

4

Project Title

비전관 스튜디오
조성공사

Approved By

Note

Drawing Title

ELEVATION-A,B,C,D
(개인녹음실 입면도)

Designed By

Drawn By

Checked By

Date 2020. 12.

Scale 1 / 50

Drawing No. I-09


Sheet No.

Project Title

비전관 스튜디오
조성공사

Approved By

Note

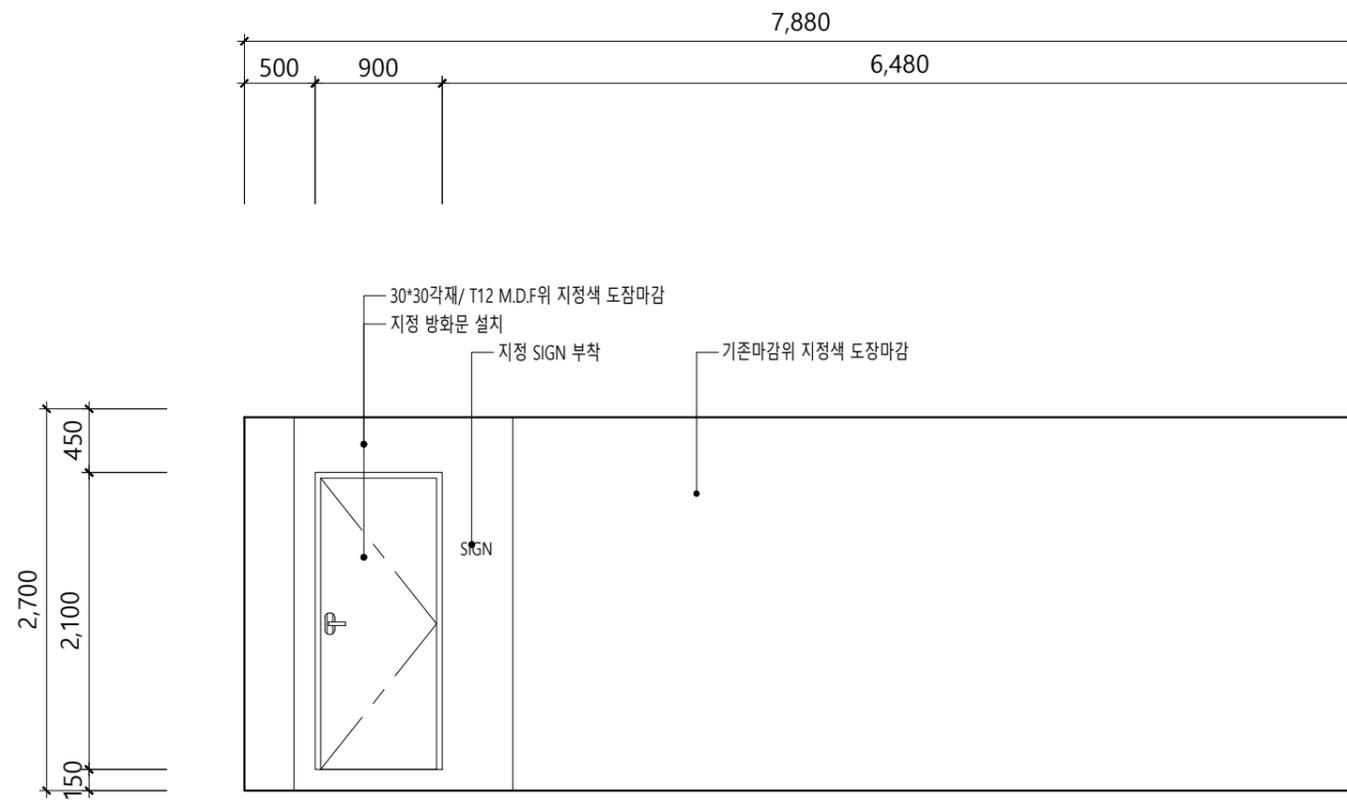

Drawing Title

ELEVATION
(입구 입면도)

Designed By

Drawn By

Checked By

Date 2020. 12.

Scale 1 / 50


Drawing No. I-10

Sheet No.


ELEVATION (입구 입면도)

SCALE
1/50


1

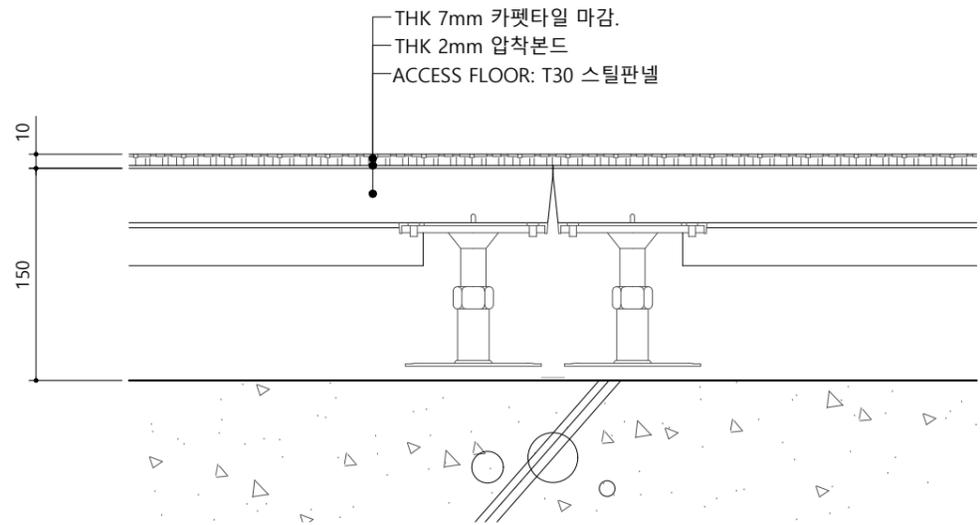


바닥상세도 SCALE 1/5 1

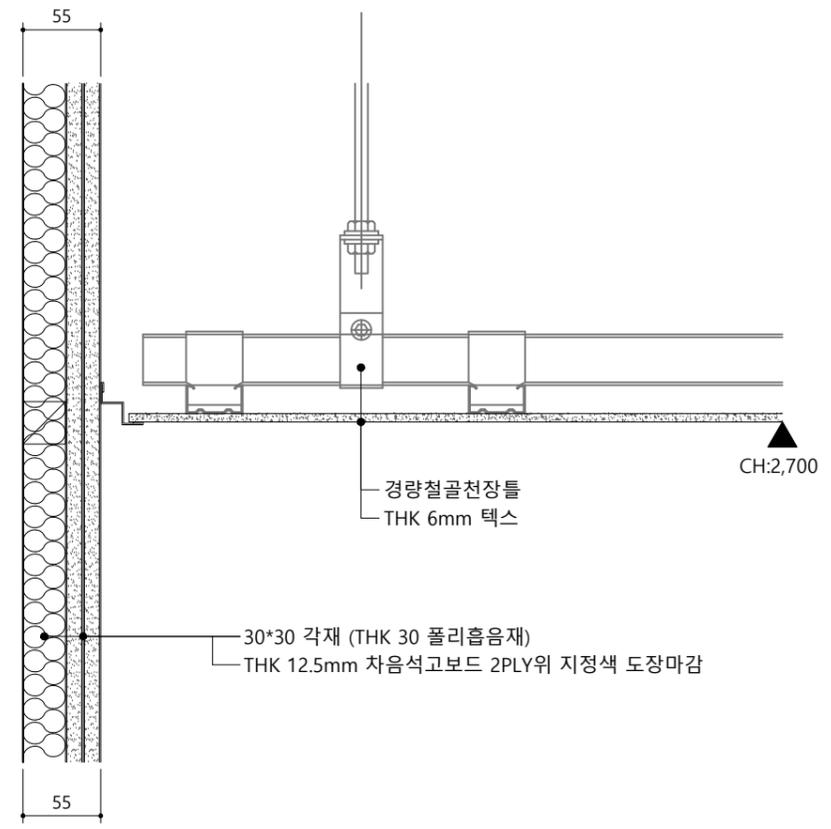

천정상세도(대기실) SCALE 1/5 2

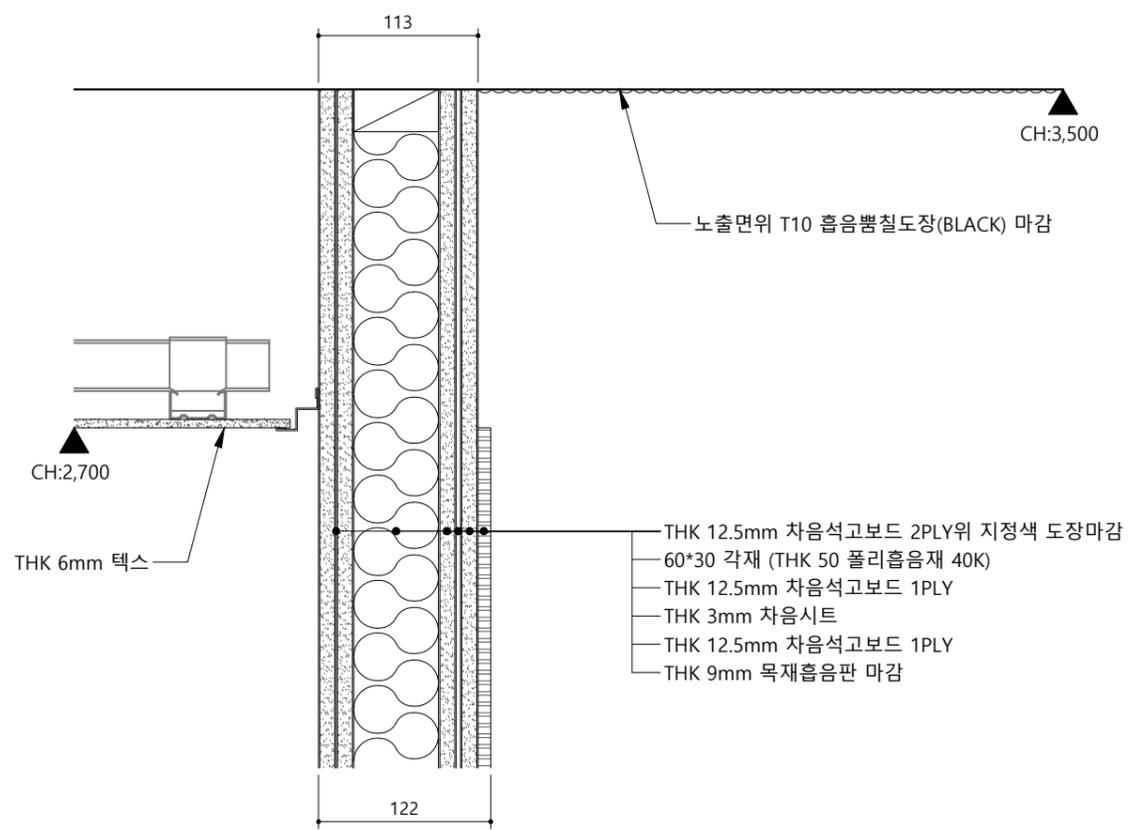

천정상세도(스튜디오) SCALE 1/5 3

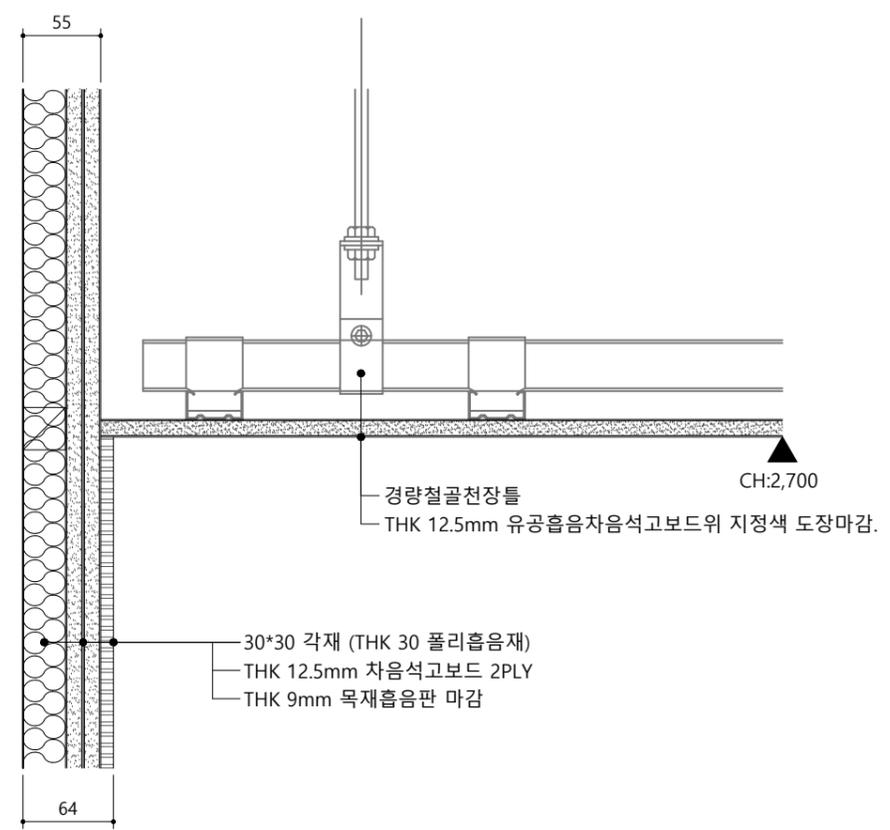

천정상세도(개인녹음실) SCALE 1/5 4

Project Title

비전관 스튜디오
 조성공사

Approved By

Note

Drawing Title

일반상세도

Designed By

Drawn By


Checked By

Date 2021. 02.

Scale 1 / 5

Drawing No. I-11


Sheet No.

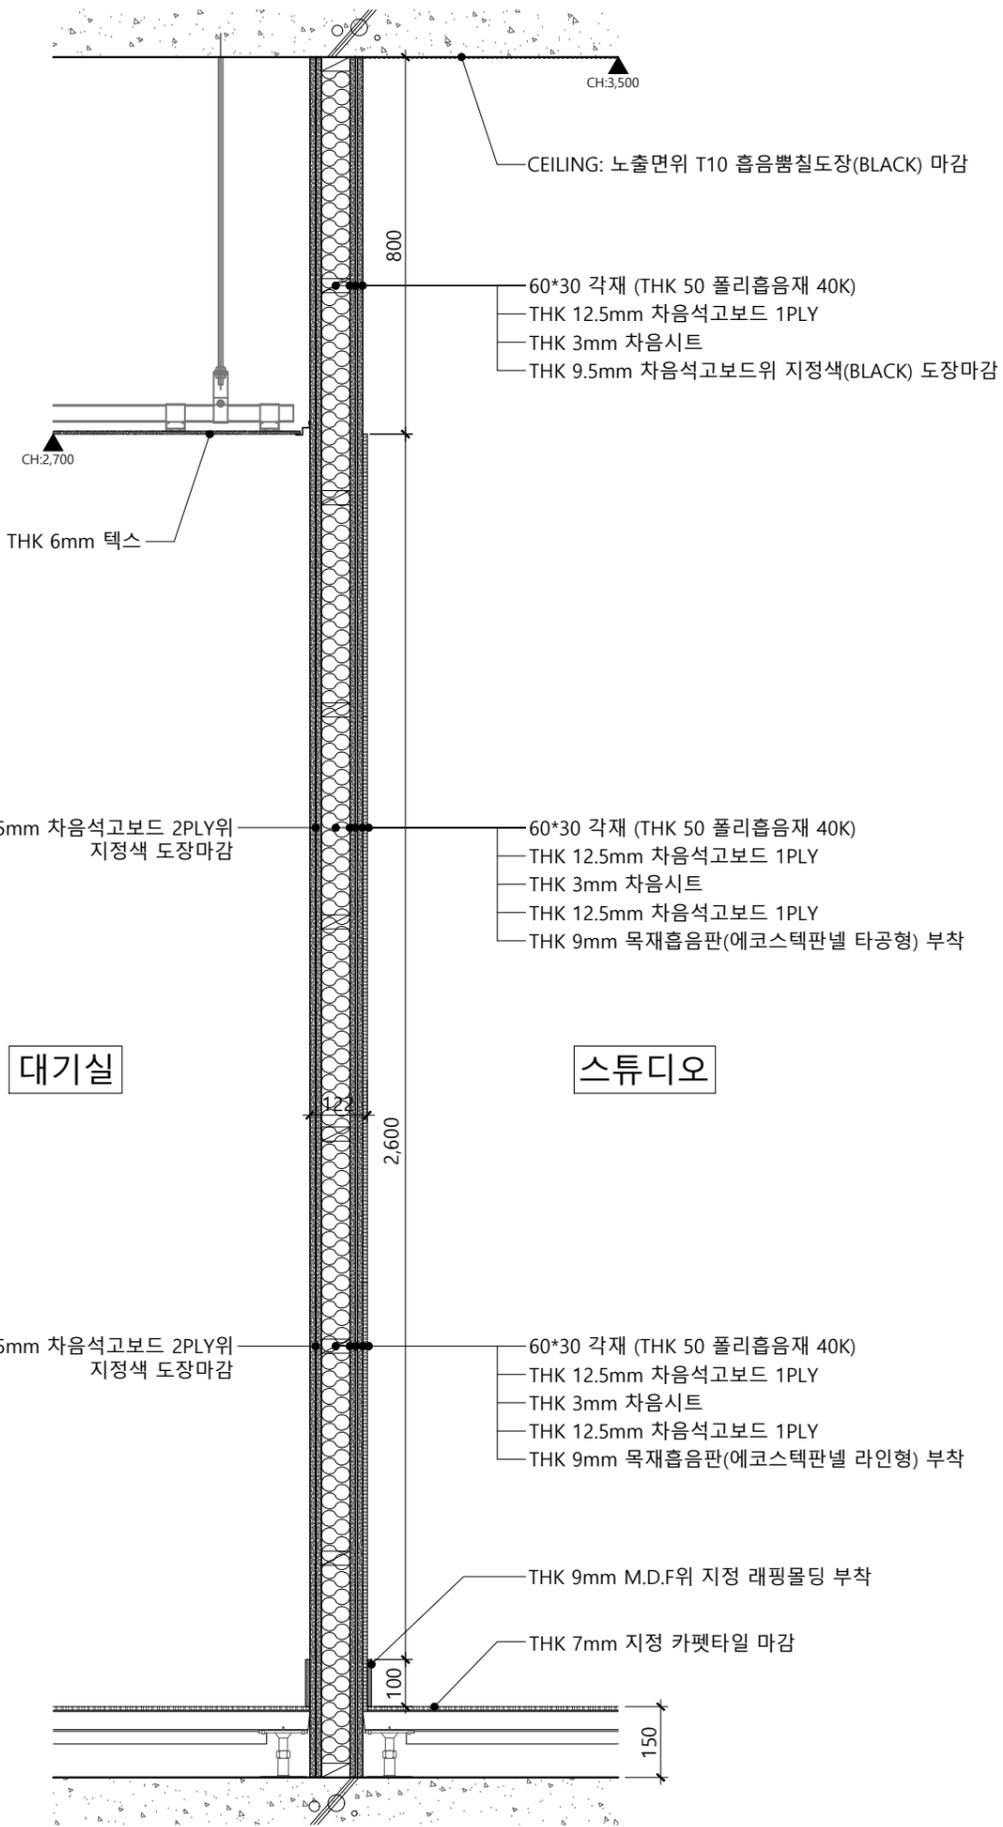

벽체상세도-1

SCALE
1/15

1

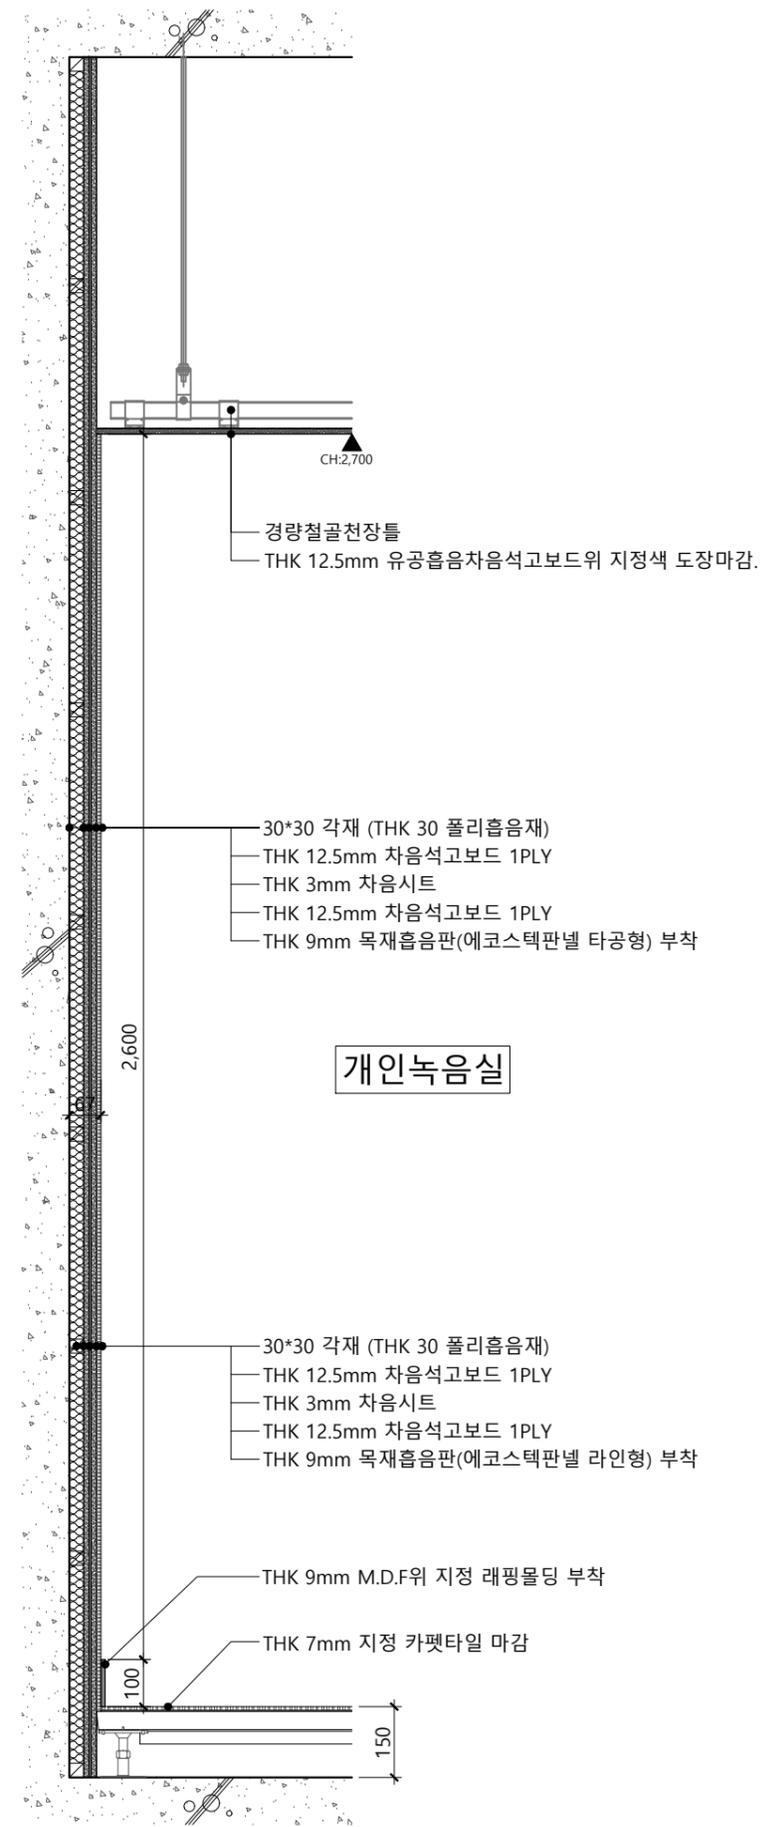

벽체상세도-2

SCALE
1/15

2

Project Title

비전관 스튜디오
조성공사

Approved By

Note

Drawing Title

벽체상세도

Designed By

Drawn By



Checked By

Date 2021. 02.

Scale 1 / 15

Drawing No. I-12

Sheet No.

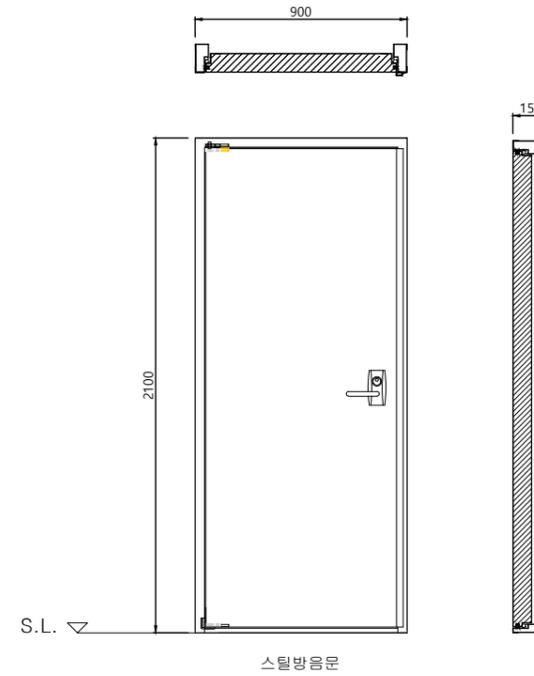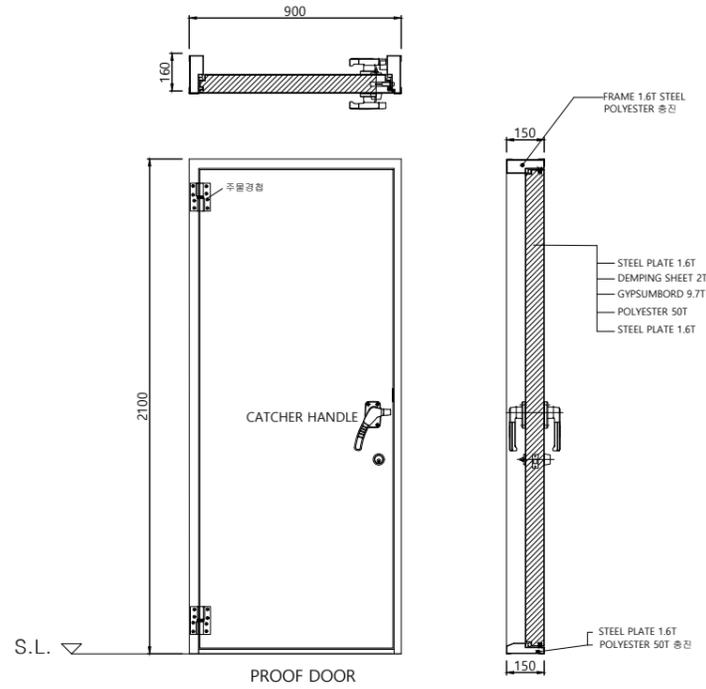

*수량: 2EA, 몰당(H=60) 양면설치

스튜디오 방음문

SCALE
1/30


1

*수량: 1EA, 몰당(H=60) 양면설치

스틸방음문

SCALE
1/30

2

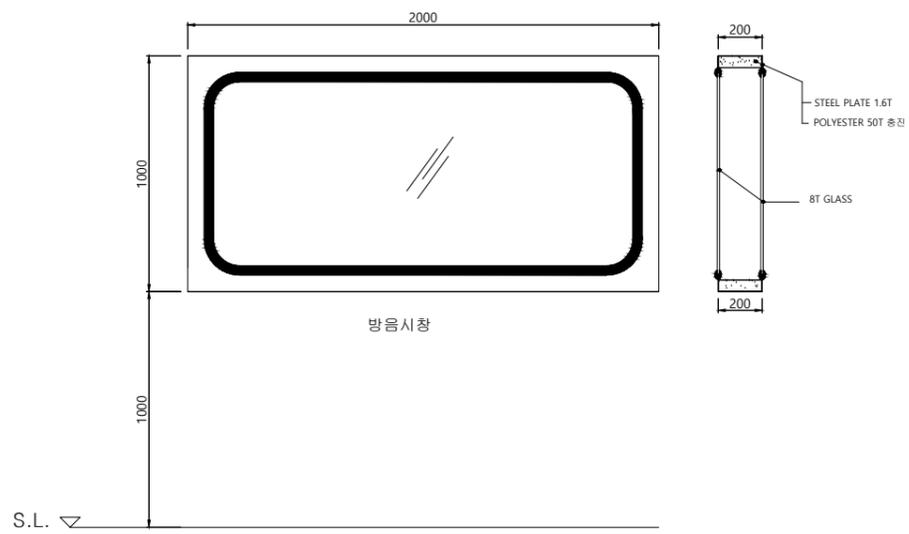

*수량: 1EA, 몰당(H=60) 양면설치

방음시창

SCALE
1/30

3

SCALE

Project Title

비전관 스튜디오
조성공사

Approved By

Note

Drawing Title

창호도

Designed By

Drawn By


Checked By

Date 2021. 02.

Scale 1 / 30

Drawing No. I-13

Sheet No.

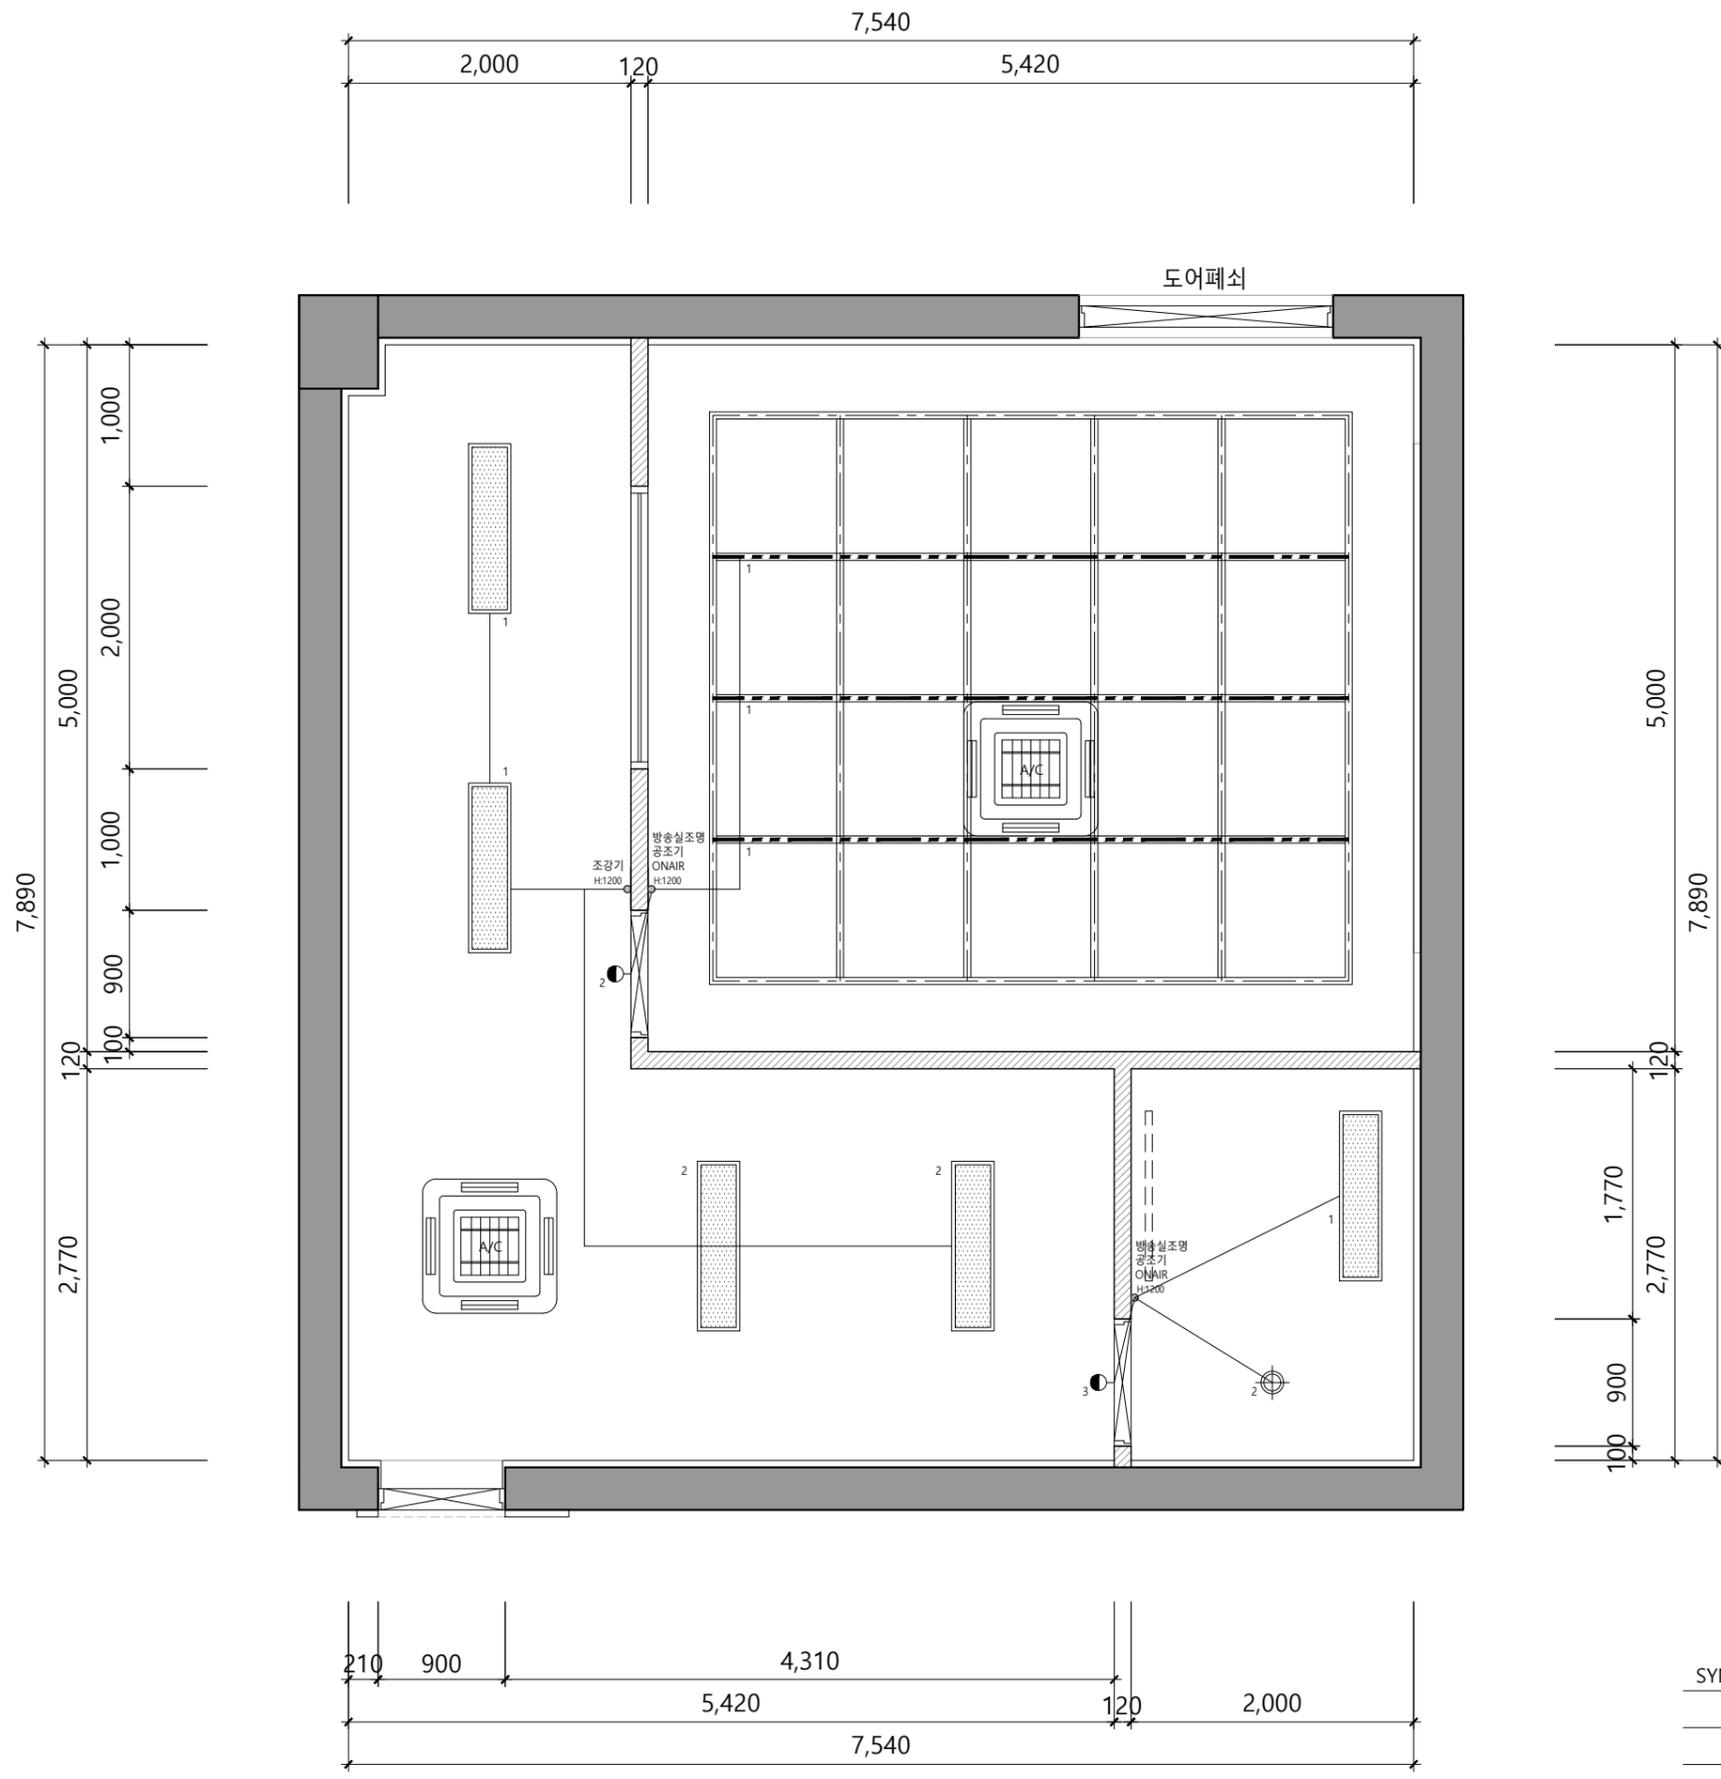

Project Title

비전관 스튜디오
조성공사

Approved By

Note

- * 면적 : 61.1m²(18.5py)
- * 천정고 : 2,360
- * SLAB : 3,500

Drawing Title

CEILING PLAN
(전등설비 배치도)

Designed By

Drawn By

Checked By

Date 2021. 02.

Scale 1 / 50

Drawing No. I-14


Sheet No.

| SYMBOLS | DESCRIPTION | 비고 |
|---------|-------------|----|
| ☐ | 시스템박스 | 5 |
| ○ | 전열 | 1 |
| ⊙ | 통신 | 15 |
| ◦ | 스위치 | 15 |

CEILING PLAN(전등설비 배치도)

SCALE
1/50

1

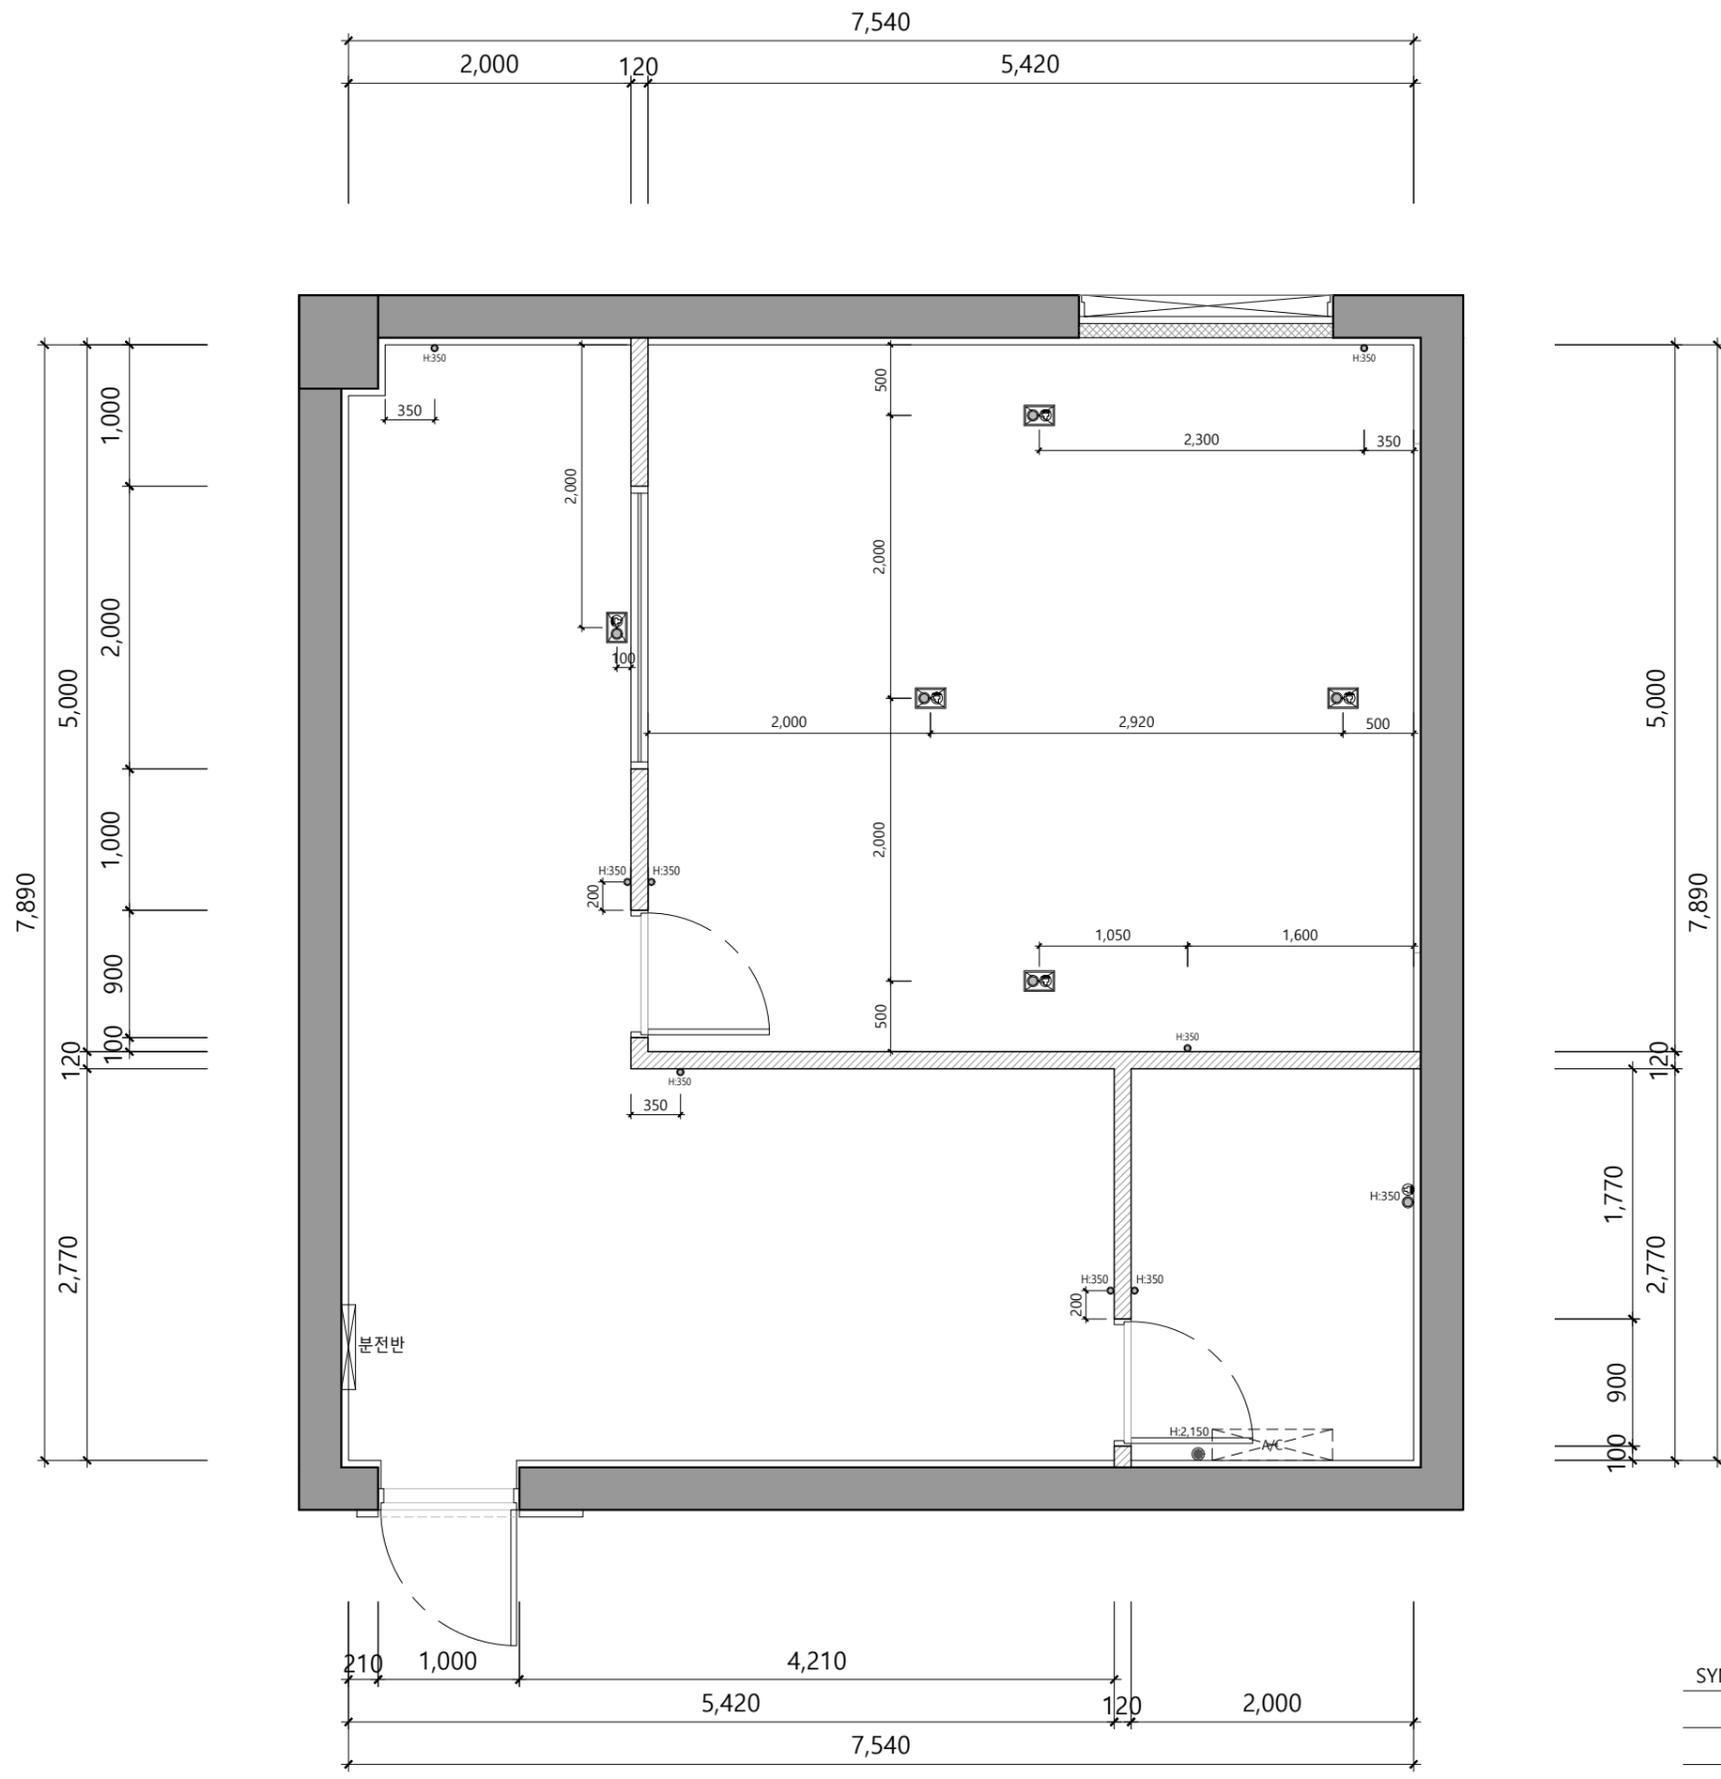


Project Title
**비전관 스튜디오
 조성공사**

Approved By _____

Note
 * 면적 : 61.1m2(18.5py)
 * 천정고 : 2,360
 * SLAB : 3,500

Drawing Title
**FLOOR PLAN
 (전열설비 배치도)**
 Designed By _____
 Drawn By _____
 Checked By _____
 Date 2021. 02.
 Scale 1 / 50
 Drawing No. I-15
 Sheet No. _____

| SYMBOLS | DESCRIPTION | 비고 |
|---------|-------------|----|
| ☐ | 시스템박스 | 5 |
| ○ | 전열 | 1 |
| ⊙ | 통신 | 15 |
| ◦ | 스위치 | 15 |

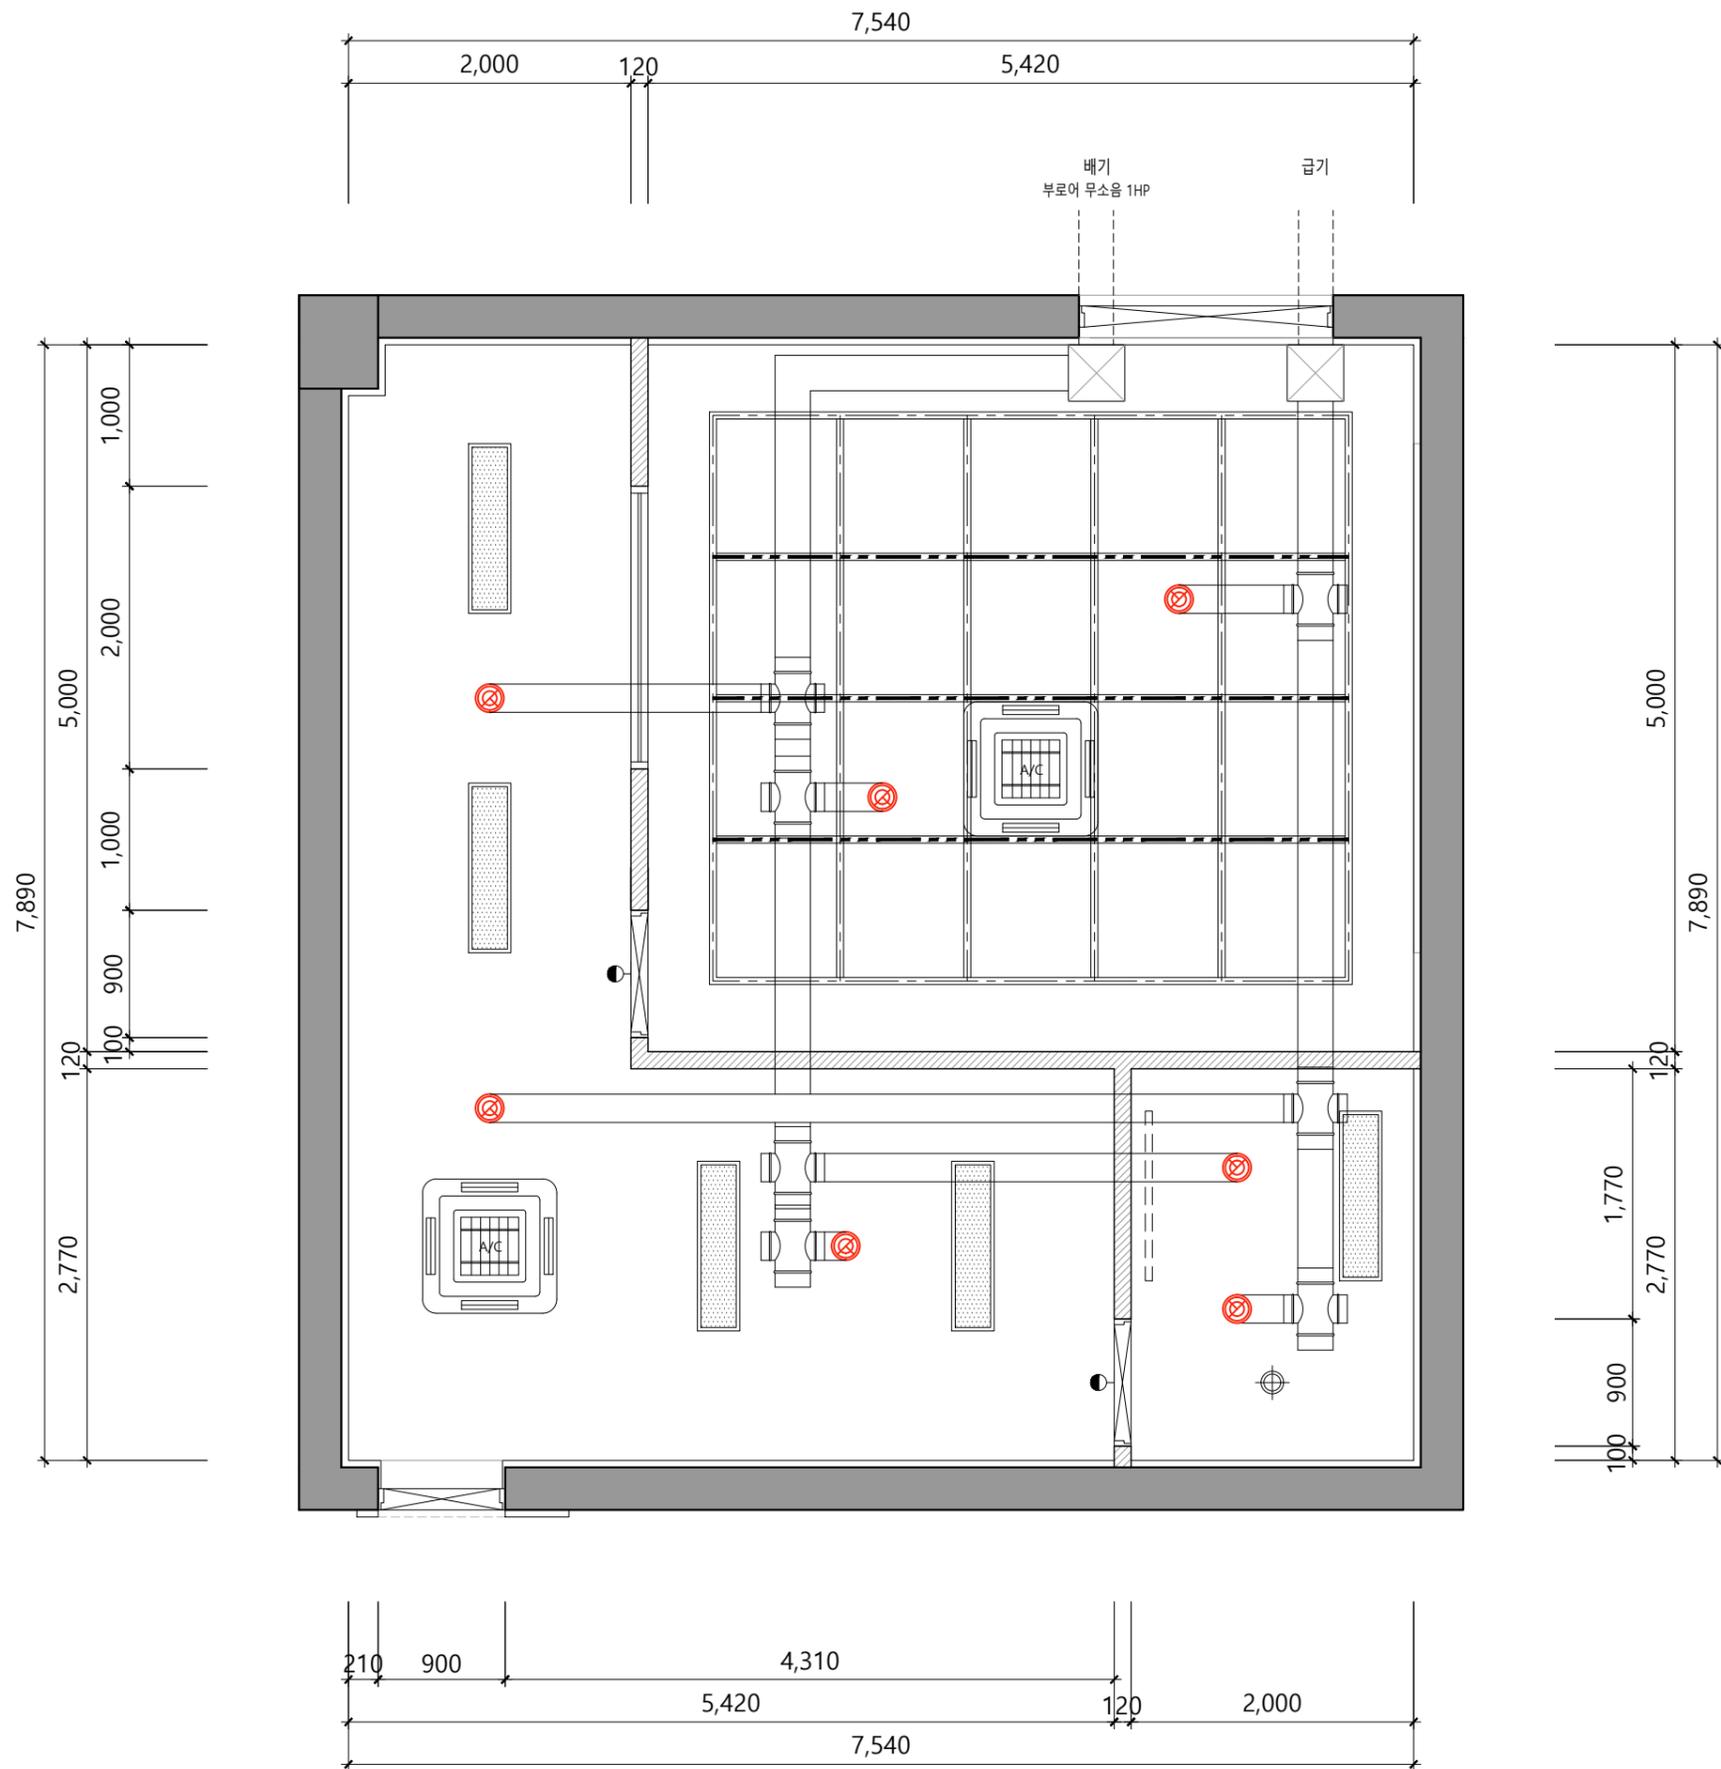

Project Title

비전관 스튜디오
조성공사

Approved By

Note

- * 면적 : 61.1m²(18.5py)
- * 천정고 : 2,360
- * SLAB : 3,500

Drawing Title

CEILING PLAN
(환기배관 배치도)

Designed By

Drawn By

Checked By

Date 2021. 02.

Scale 1 / 50

Drawing No. I-16

Sheet No.